


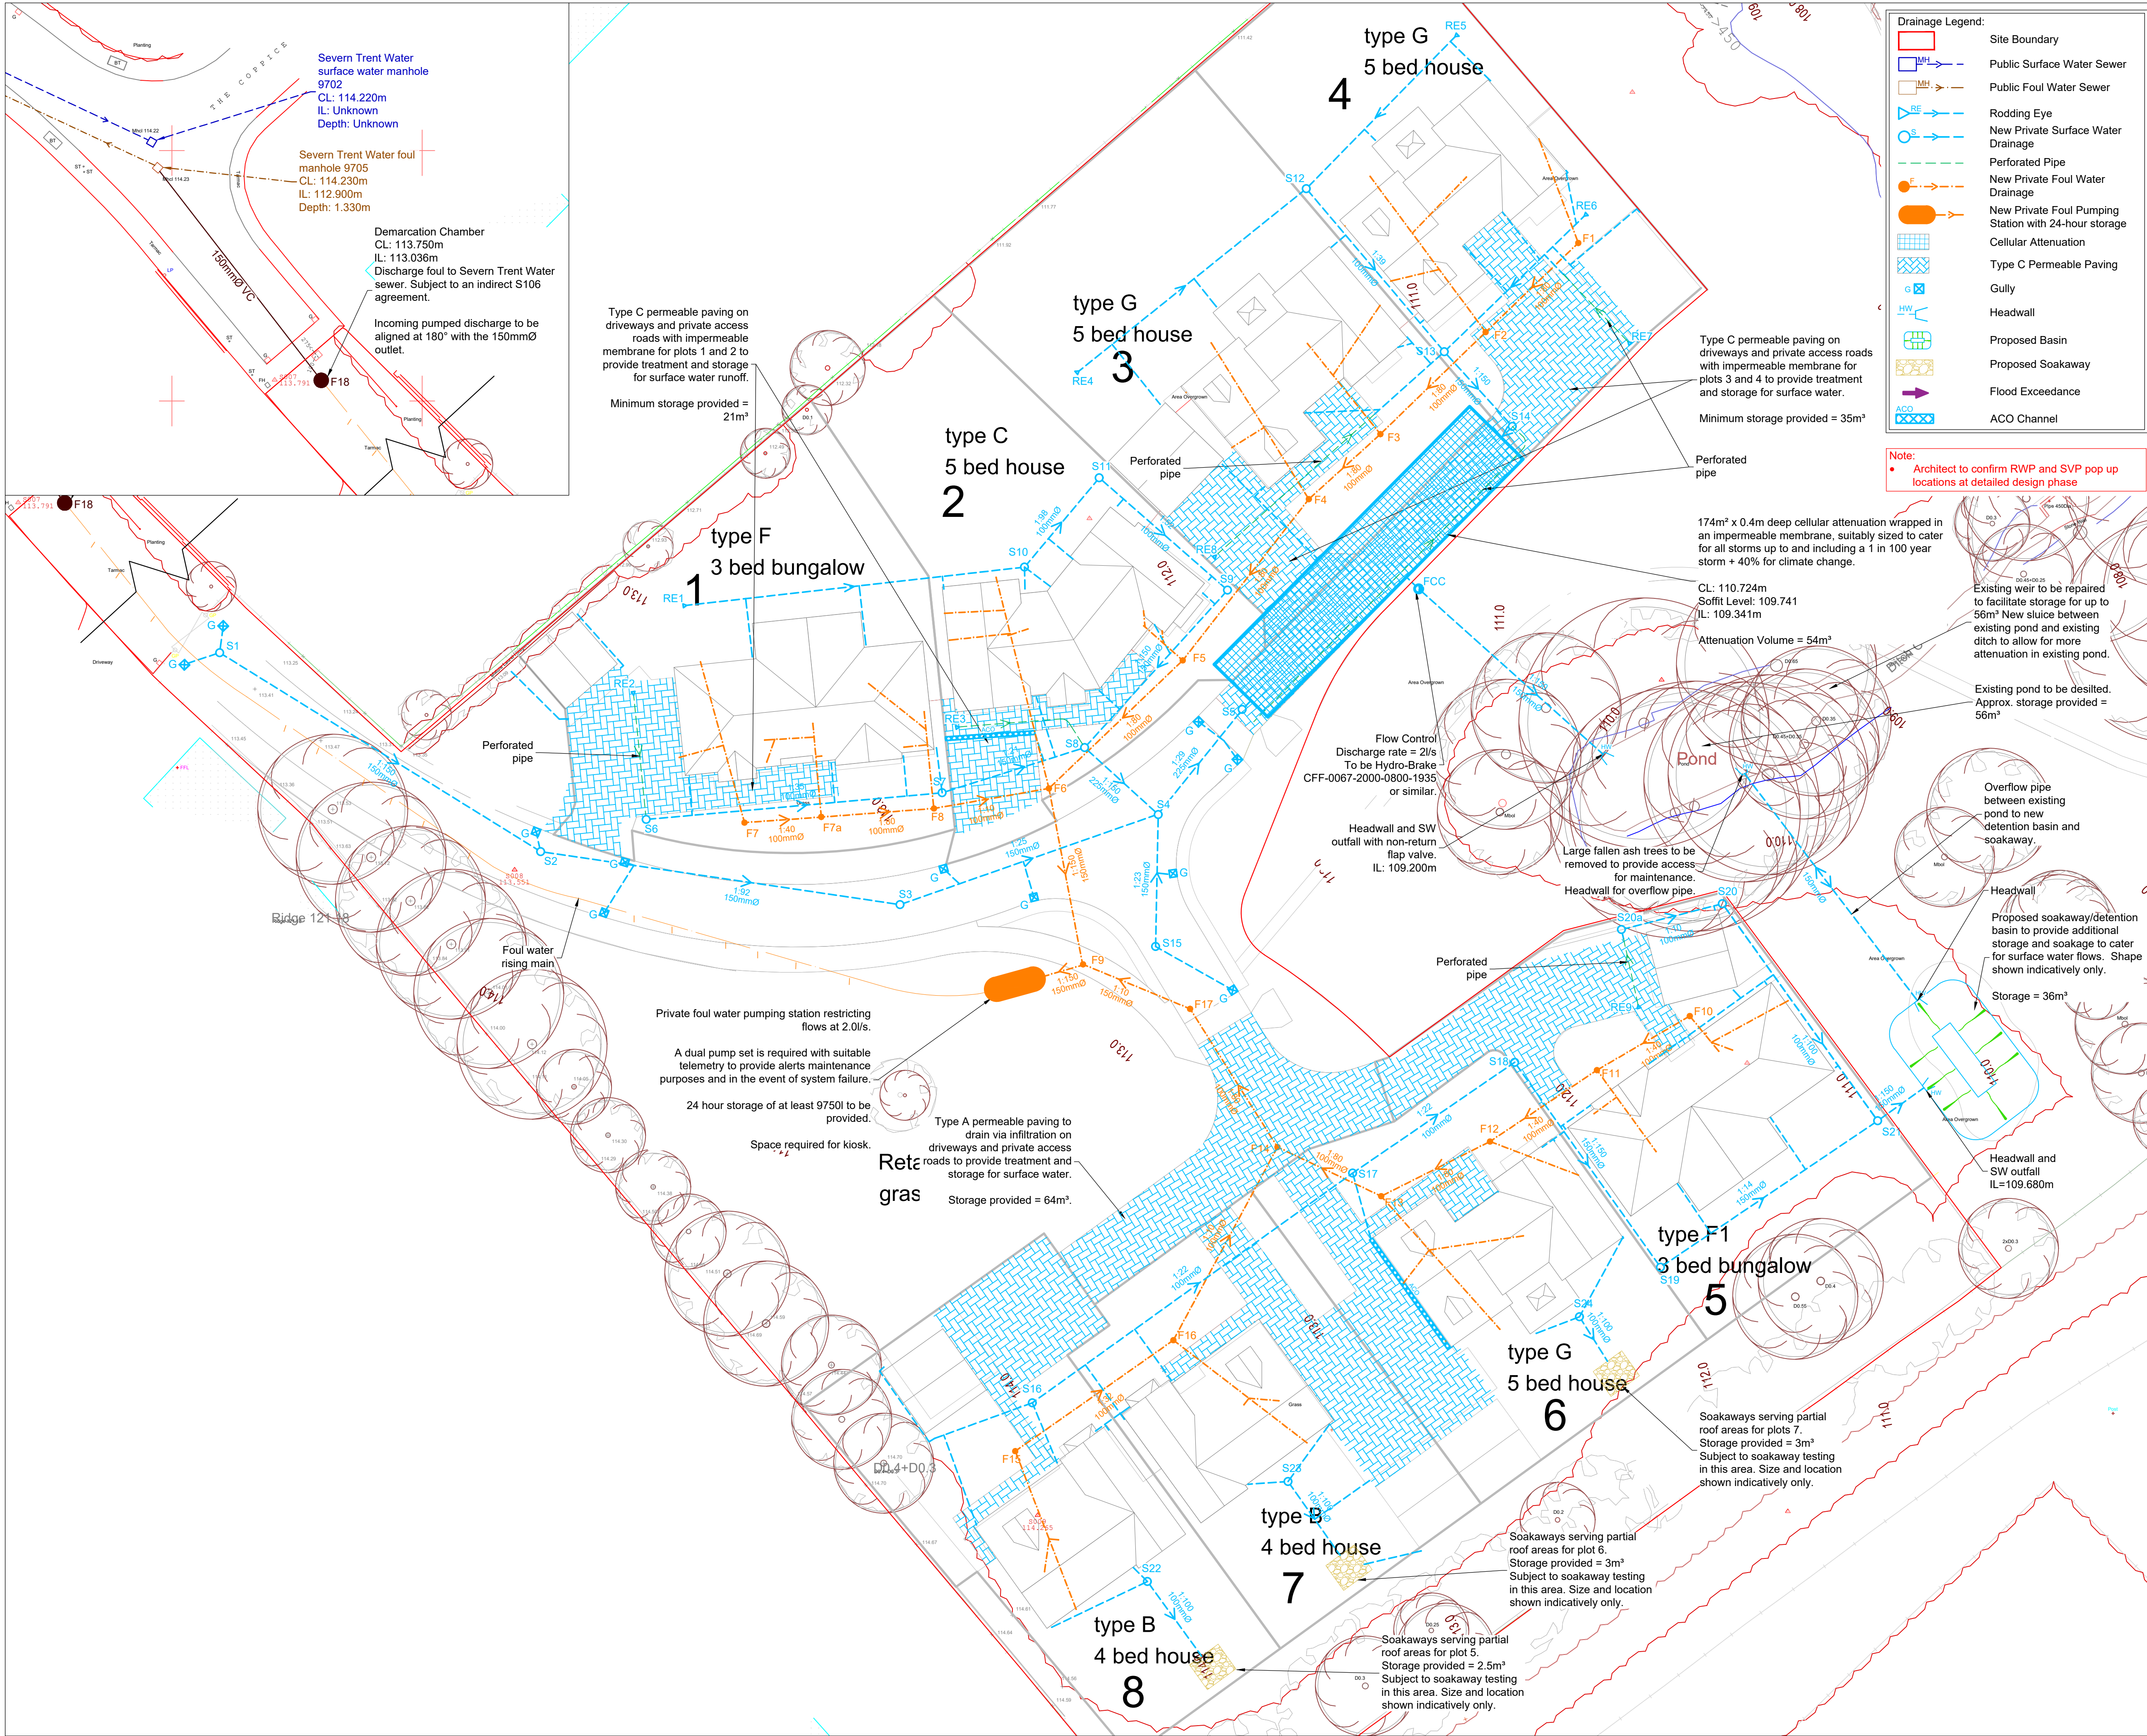

SAFETY, HEALTH & ENVIRONMENTAL HAZARD INFORMATION BOX.

The hazards noted below are in addition to the normal hazards and risks faced by a competent contractor when dealing with the types of works detailed on this drawing.

CONSTRUCTION RISKS:

- Deep Trenches
- Unforeseen Services
- Leptospirosis

Notes:

1. DO NOT SCALE FROM THIS DRAWING.
2. All dimensions are in millimetres Unless Noted Otherwise (u.n.o.)
3. Drawing is to be read in conjunction with all relevant architect's drawings. Any inconsistencies should be reported to PRP immediately.
4. All levels and dimensions are to be checked on site before any work commences.
5. The Health and Safety at Work act is to be complied with at all times. Attention is drawn to the wearing of hard hats, reflectorised clothing, and the use of any other required safety equipment.
6. Print in colour

Drainage:

1. The position, line, level and diameter of all existing drainage apparatus should be confirmed on site prior to the commencement of the works. Any discrepancies should be reported to PRP immediately.
2. The connection of foul and surface water drainage to the existing public sewer system shall be subject to the approval of the water authority
3. For positions of all rainwater pipes & foul outlets refer to Architect's drawings.
4. Drainage designed in accordance with the Sewerage Sector Guidance, Design and Construction Guidance ("the Code") Approved Version 2.0, 10 March 2020 and Building Regulations Part H.
5. All joints between precast manhole components shall have a minimum uncompressed thickness of 10mm of proprietary bitumen or resin mastic sealant.
6. Storm & foul branch connections are to be laid at gradients of between 1:10 & 1:80
7. All in-situ concrete shall be minimum grade GEN3.
8. Precast concrete cover & reducing slabs to be heavy duty reinforced concrete to BS 5911.
9. Rising mains shall be black MDPE SDR11 as WI 4-32-03 & joints & fittings to be in accordance with WI 4-32-04. Other approved pipe materials to be in accordance with their relevant BS.
10. Manhole covers & frames shall be manufactured in cast iron or ductile iron & shall comply with requirements of BS EN 124 & shall be kite marked or equivalent.
11. All completed work shall be suitably protected from damage by construction work. Damaged drainage will not be accepted. It is recommended that no heavy loading or underground work is permitted above or near unprotected drainage, and that dumpers, trucks, fork lifts or other heavy vehicles are not driven along or near pipe runs.
12. Inspection chambers, and flow control units are to be installed strictly in accordance with manufacturer guidance and instructions
13. All drainage works to be constructed to Building Regulations Part H and PRP specification.
14. Foul pipes to be wrapped in an impermeable membrane where they cross permeable paving, to prevent any surface water seepage.

P2	30/09/2024	Issued for comments. Site plan updated.	VSP/ DE
P1	26/09/2024	Issued for comments	VSP/ DE
Rev	Date	Description	By / Chk

PRP
consulting engineers & surveyors

Catherine House
Old Harborough Road
Brixworth, NN6 9BX

Telephone: 01604 889 870
northampton@prp.co.uk
www.prp.co.uk

Leicester
Northampton
London

engineering excellence | creating advantage

Client:
Springbourne Homes Ltd

Architect:
Hayward Architects

Project:
Proposed Housing Development
The Coppice
Burbage

Title:
Proposed Drainage Layout

Status:
PRELIMINARY

Engineer:	VSP	Date:	September 2024
Drawn:	VSP	Scales @ A1:	1:250
Checked:	DE		
Project No:	82907	Drg No:	102
		Rev:	P2

copyright all rights reserved PRP.UK Ltd 2010