 





Heat Pump
location



Rev:	Description:	By:	Date:
------	--------------	-----	-------

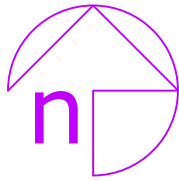

octopusenergy
services

Accredited by:



Client/Project: Ashley Fulham 9 Equity Road East Earl Shilton LE9 7FZ	Project status: PLANNING (installation of air source heat pump)
	Drawing title: Site plan as proposed

Scale: 1:200	Paper Size: A3	Drawn: D. Rodriguez	Checked:
Project ID: J-29773D68	Drawing No: 03	Revision: -	Date: 13.07.2026