
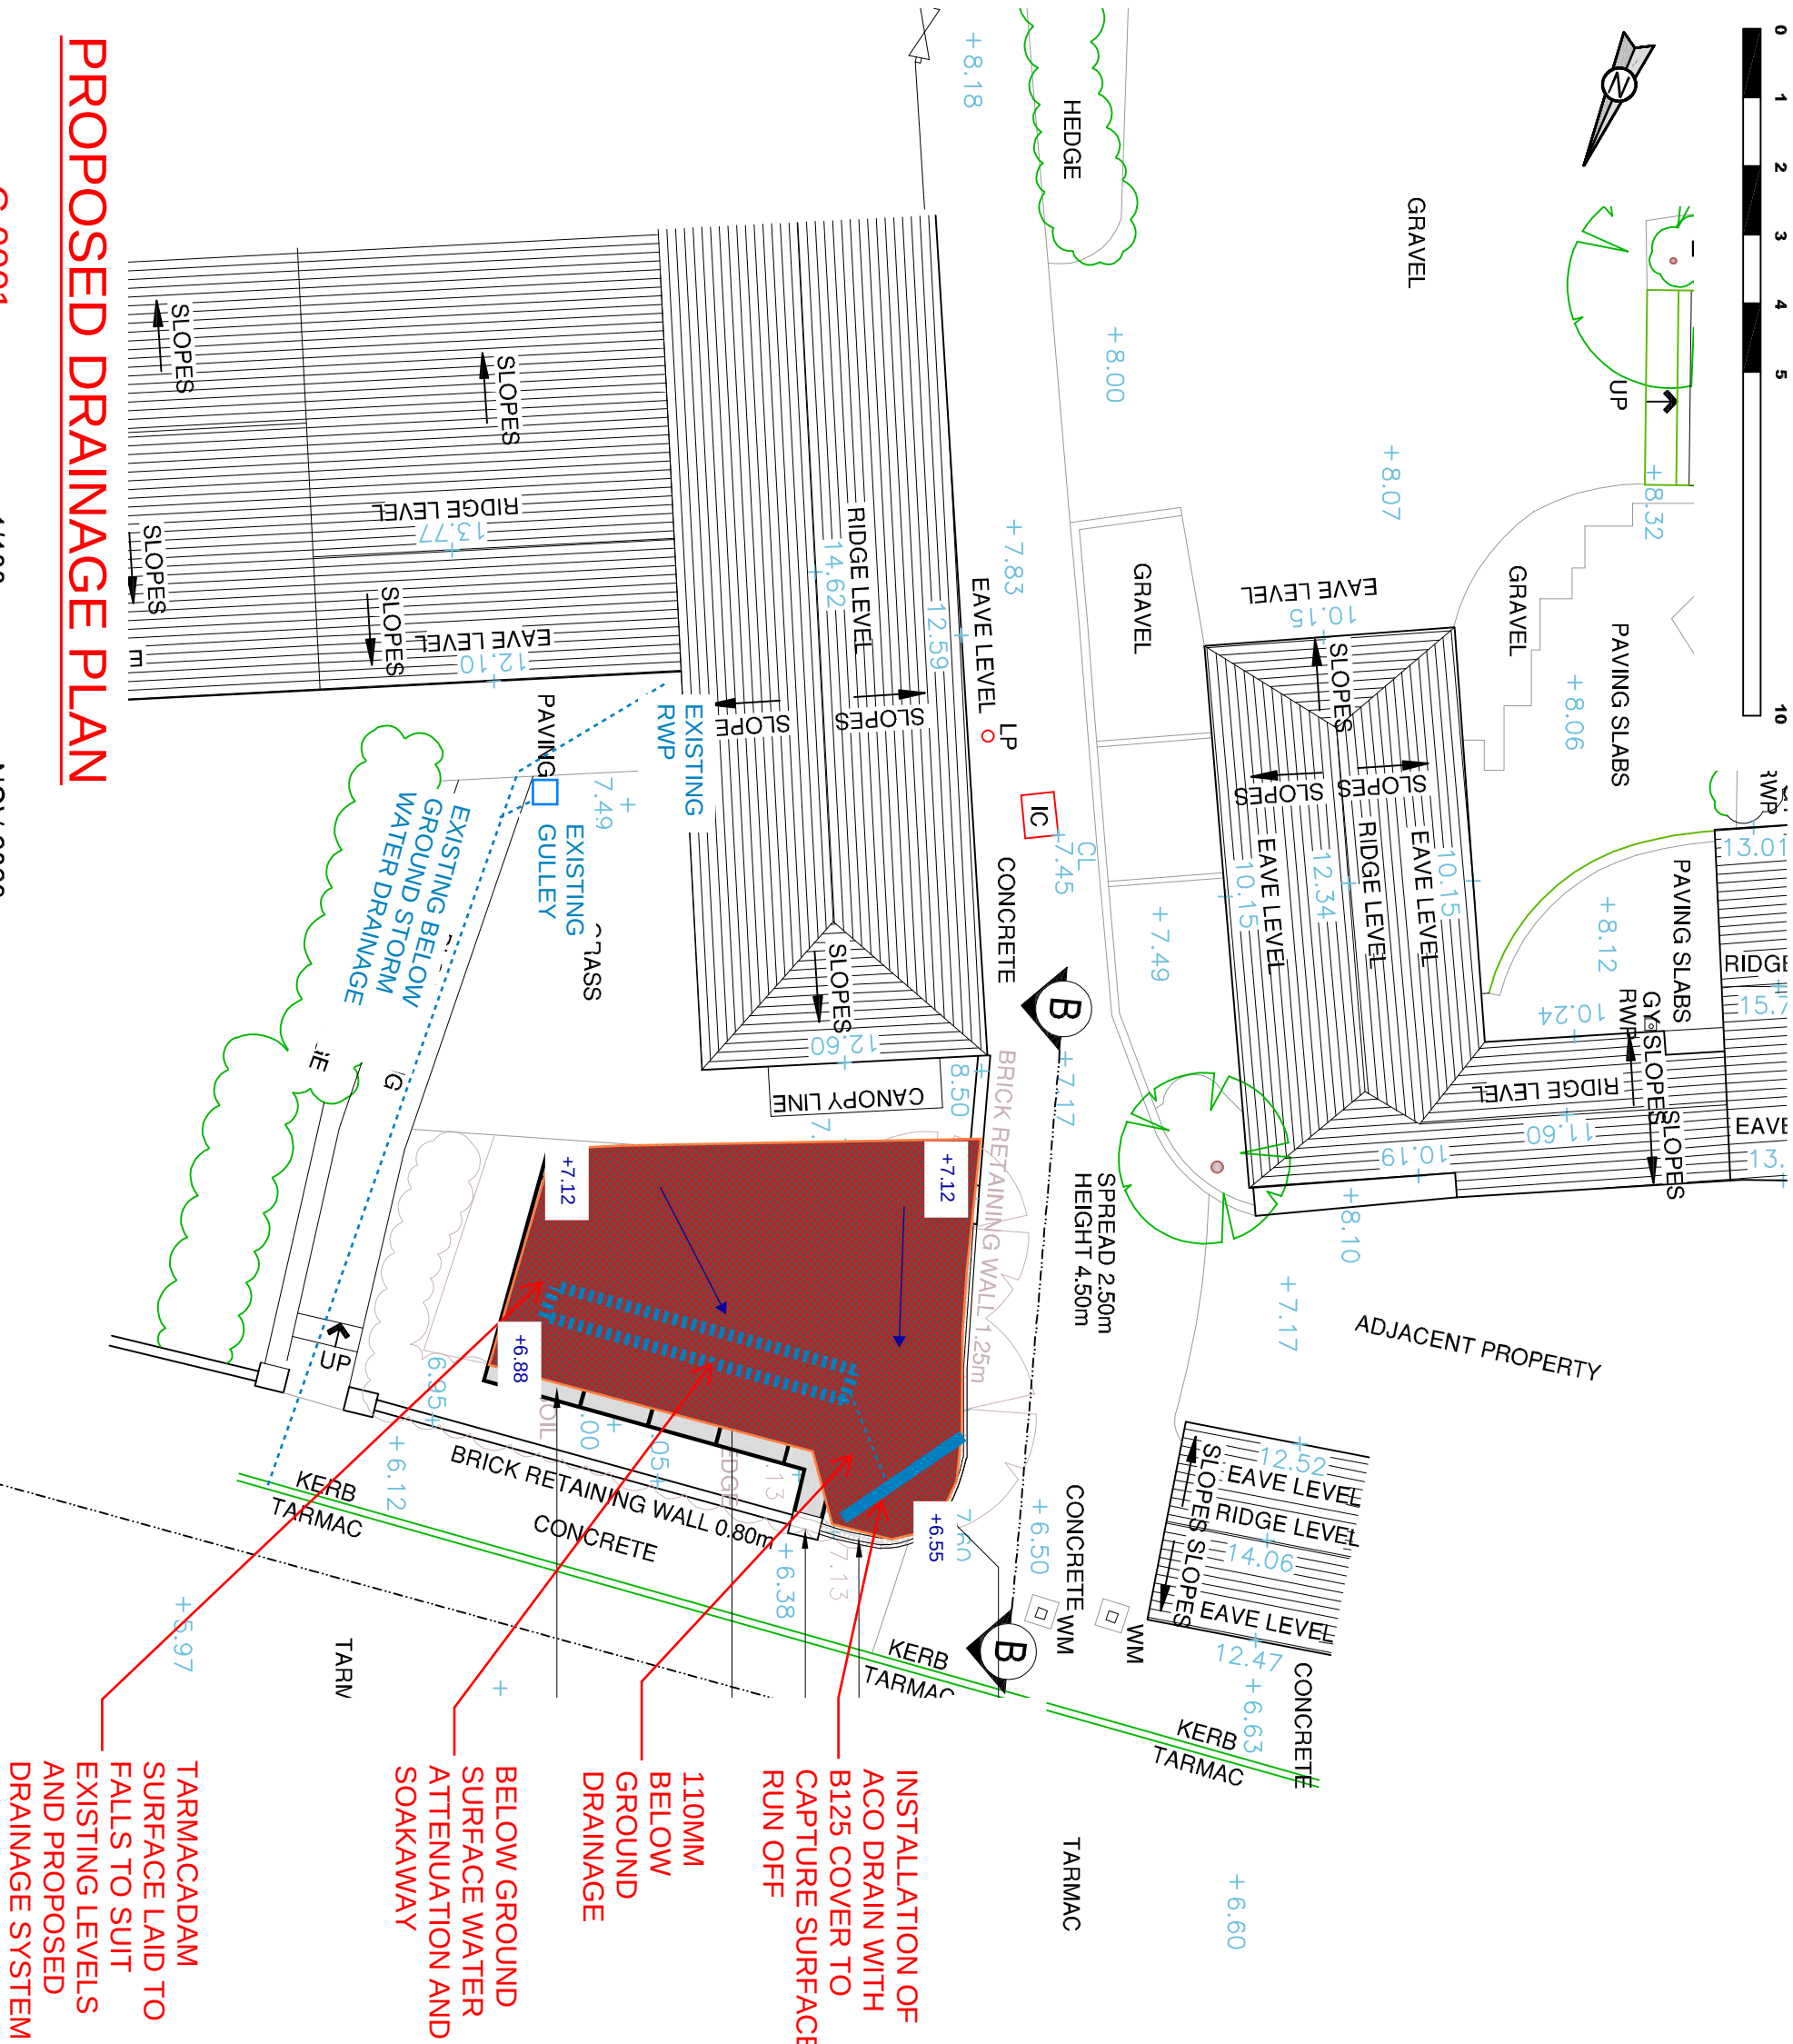


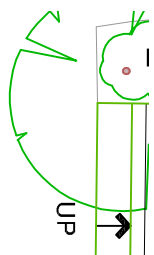


This drawing is copyright 2023 © and must not be reproduced in whole or part without obtaining written authority from MDCS GROUP.  
This drawing is to be read in conjunction with all other relevant Architect, Structural Engineer or third party drawings.  
All dimensions are to be checked on site against site conditions and any discrepancy advised to the designer before any works commence.  
DO NOT SCALE THIS DRAWING

- KEY
- +6.55

PROPOSED LEVEL
- ↓

PROPOSED FALL
- ACO DRAIN
- UNDER GROUND STORM DRAINAGE
- |||||

ATTENUATION AND SOAKAWAY

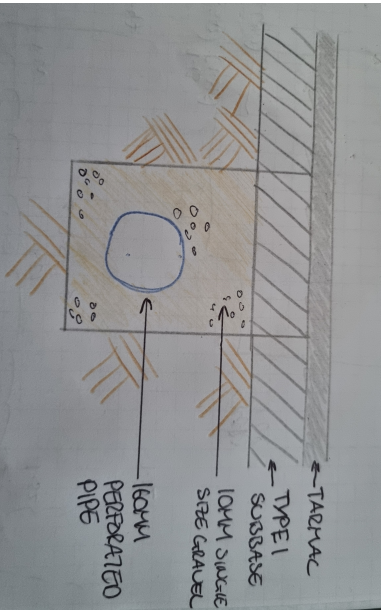

PROPOSED DRAINAGE PLAN

DWG NO: C-0001 - SCALE: 1/100 @A3 - DATE: NOV 2023

56 HIGH STREET, DESFORD, LEICESTER, LE9 9JF

SOAKAWAY DETAIL

160MM DIAMETER PERFORATED PIPE SURROUNDED WITH 150MM SINGLE SIZED 10MM GRAVEL SURROUND