
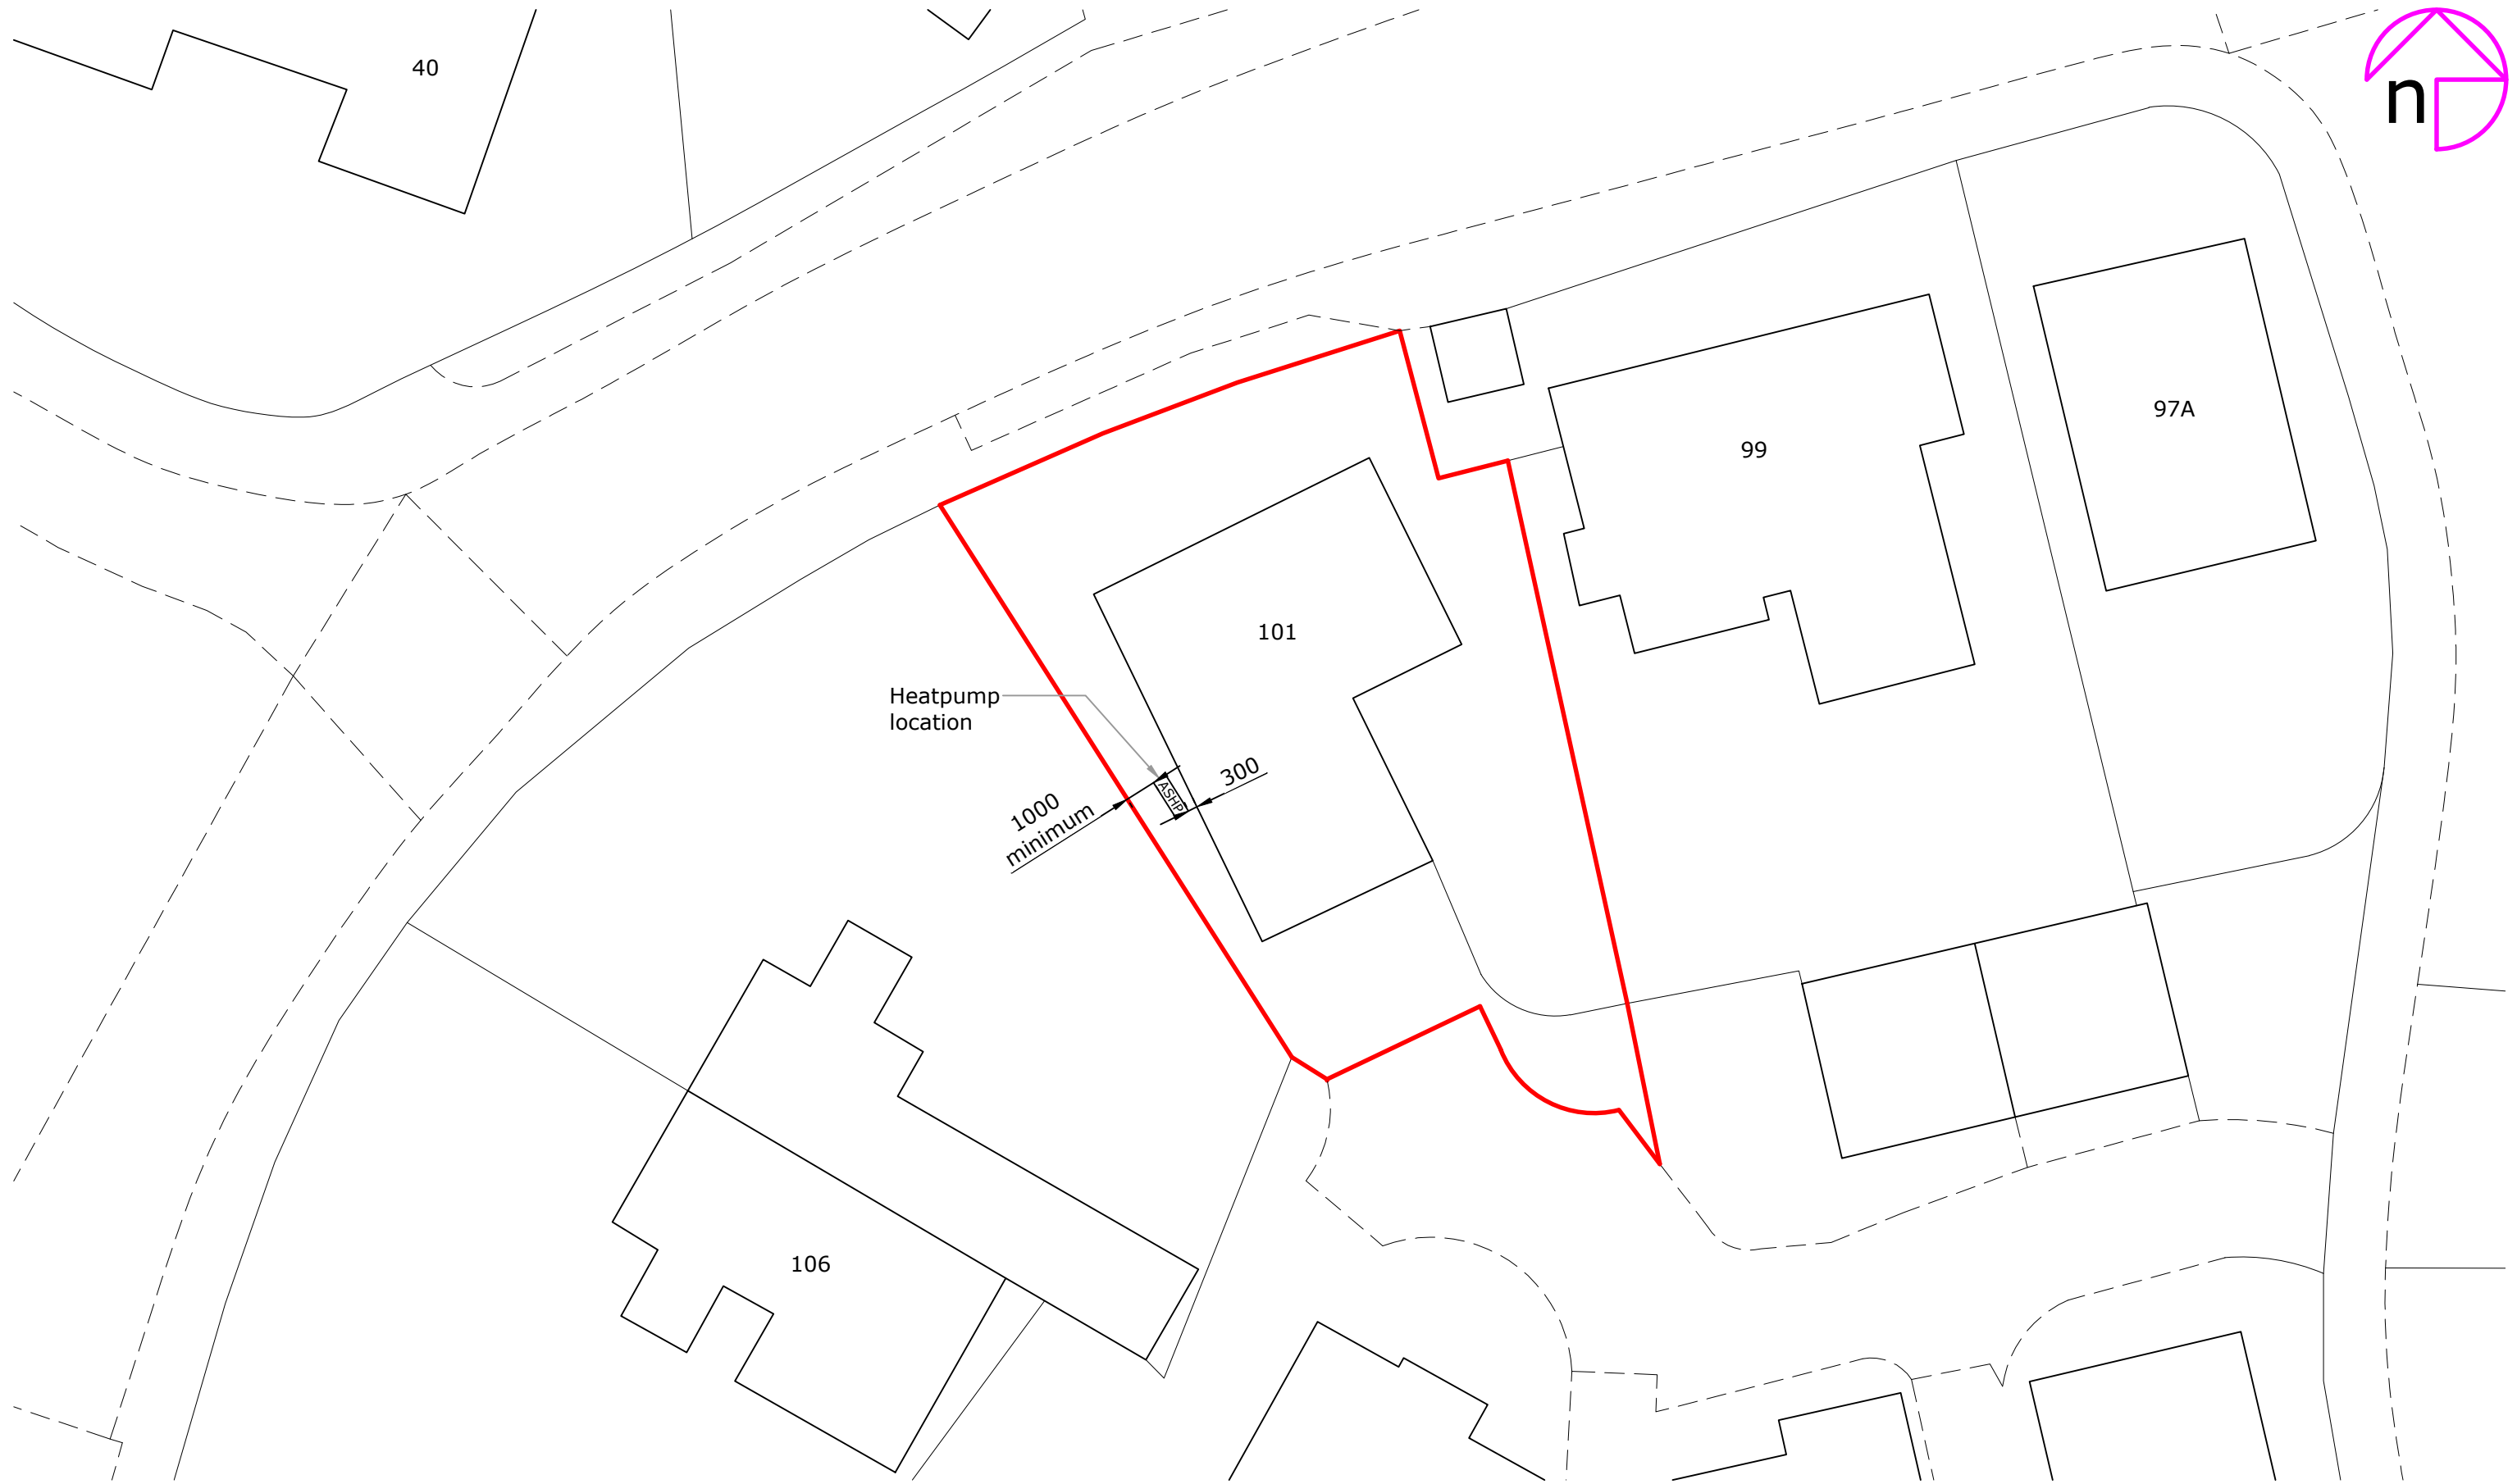


Rev:	Description:	By:	Date:
------	--------------	-----	-------

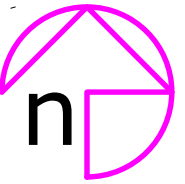

Accredited by:

Client/Project: Neil Morgan, 101 Barton Road, Congerstone, Shackerstone, CV13 6NB	Project status: PLANNING (installation of air source heat pump) Drawing title: Site plan as proposed
--	--

Scale: 1:200	Paper Size: A3	Drawn: A Walton	Checked: P H Brown
Project ID: J-ABA42CBE	Drawing No: 03	Revision:	Date: 06.06.2024