


Contractors responsibility to check all site dimensions & levels prior to commencing works.
Contractor to comply in all respects with current building regulations & guidelines whether specified on this drawing or not.
The drawing must be read & checked against any other specialist drawings provided by the company or by consultants.
This drawing and the works depicted are the copyright of the company & may not be replicated without written permission.

KEY

- N1 General Fire Notice
- N2 Staff Fire Notice
- N3 'Fire Door Keep Locked' sign
- N4 'Fire Exit Keep Clear' sign
- N5 'Fire Door Keep Locked' sign
- FB Fire Blanket
- DP Dry Powder Fire Extinguisher
- CO Carbon Dioxide Fire Extinguisher
- FO Foam Fire Extinguisher
- WA Water Fire Extinguisher
- E1 Emergency Light Fitting
- EE Emergency Exit Sign
- H Heat Detector
- S Smoke Detector
- Break Glass Call Point
- Fire Alarm Sounder
- FAP Fire Alarm Panel
- AWP Amusement with Prizes
- SWP Skill with Prizes
- ATM Cash machines
- PP Pay Phone
- J Juke Box
- C Cigarette M/c

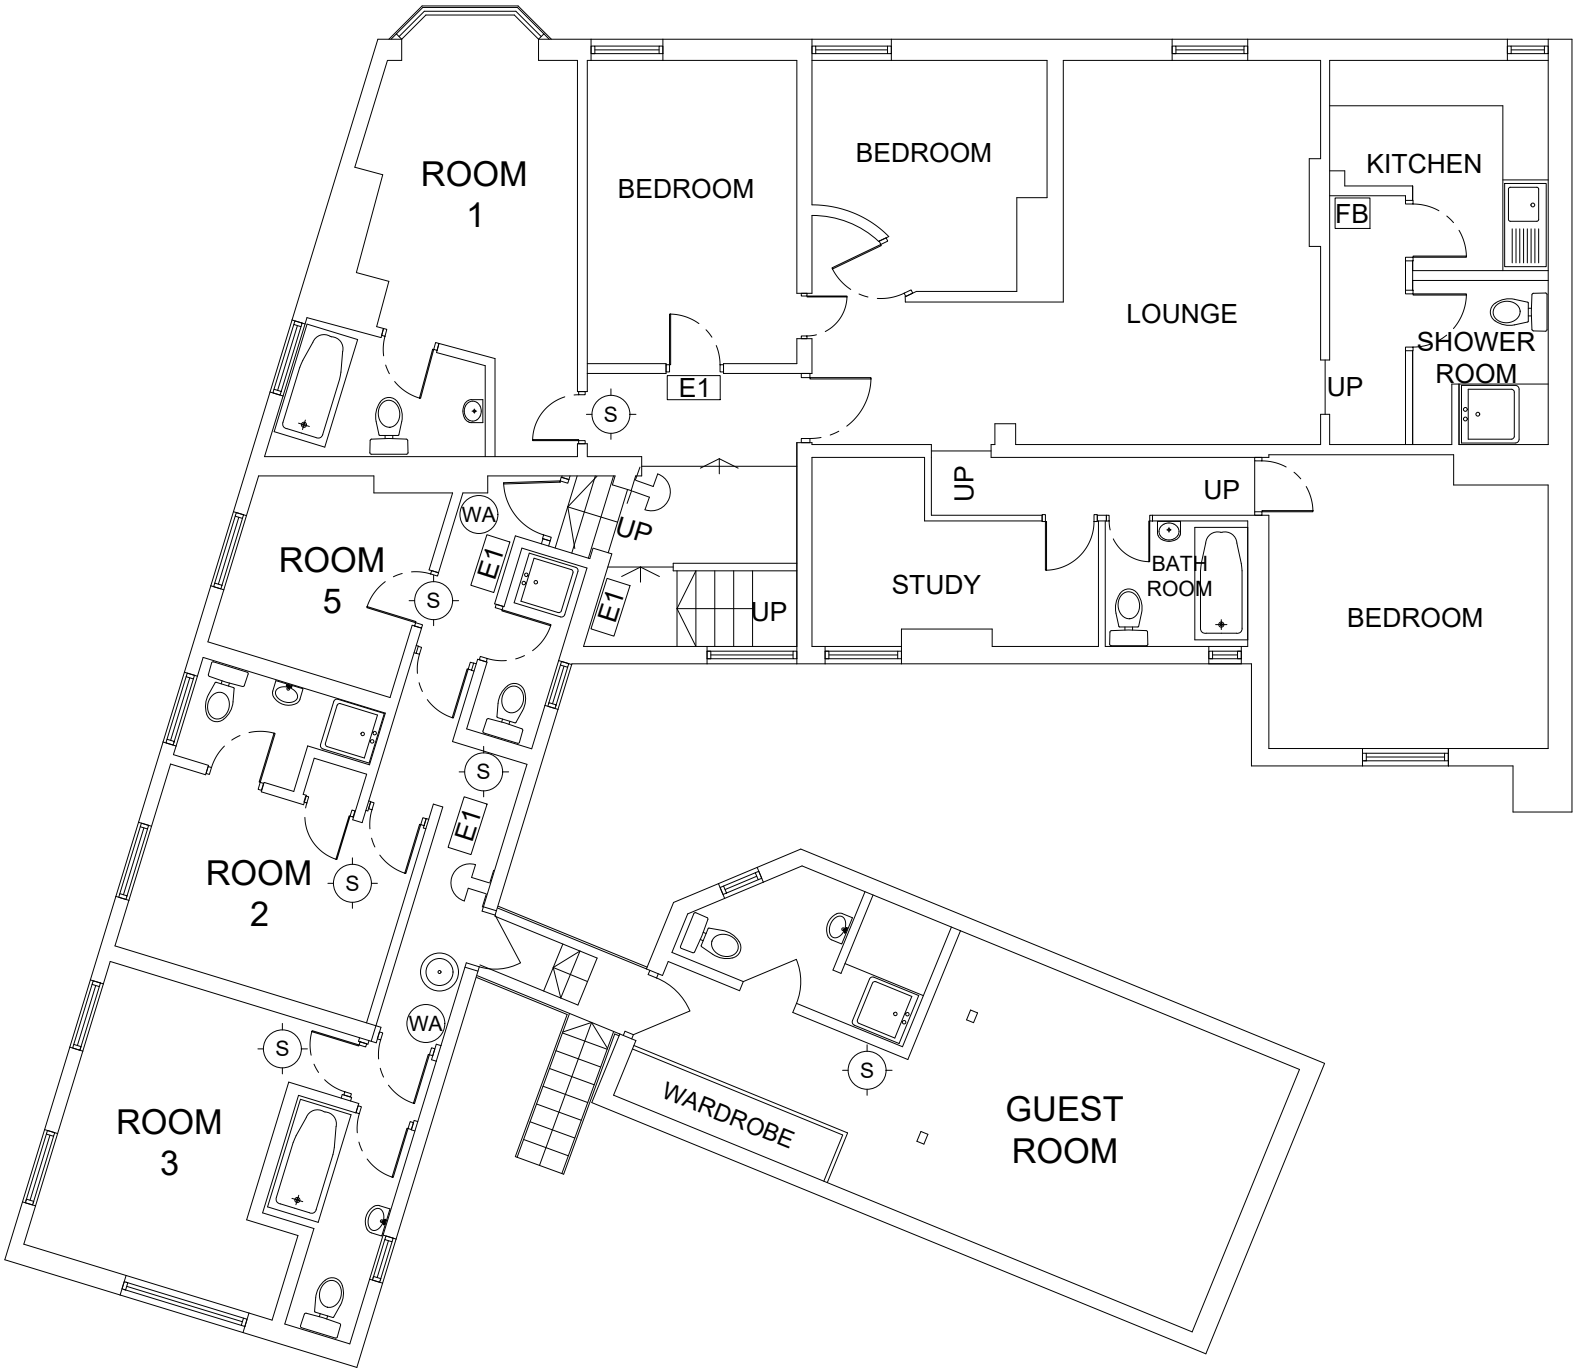

REV	DETAILS	BY
		
MARSTON'S		
PROJECT Ye Olde Red Lion 1 Park Street, Market Bosworth, Nuneaton, CV13 0LL		
TITLE Existing First Floor Plan		
SCALE 1:500 @ A3		DATE MAY 2023
DRAWN BY AF	CHECKED BY -	DRAWING No. 05/05/9631/EX/FFP
REV -		BY -
MARSTON'S PLC ST JOHNS HOUSE ST JOHNS SQUARE WOLVERHAMPTON WV2 4BH TEL:01902 907250		