



SPRINKLER TANKS AND
PUMPHOUSE DETAILS BASED
ON ALPINE DRAWING
AFE-12912-01-01-A
AFE-12912-01-09-A

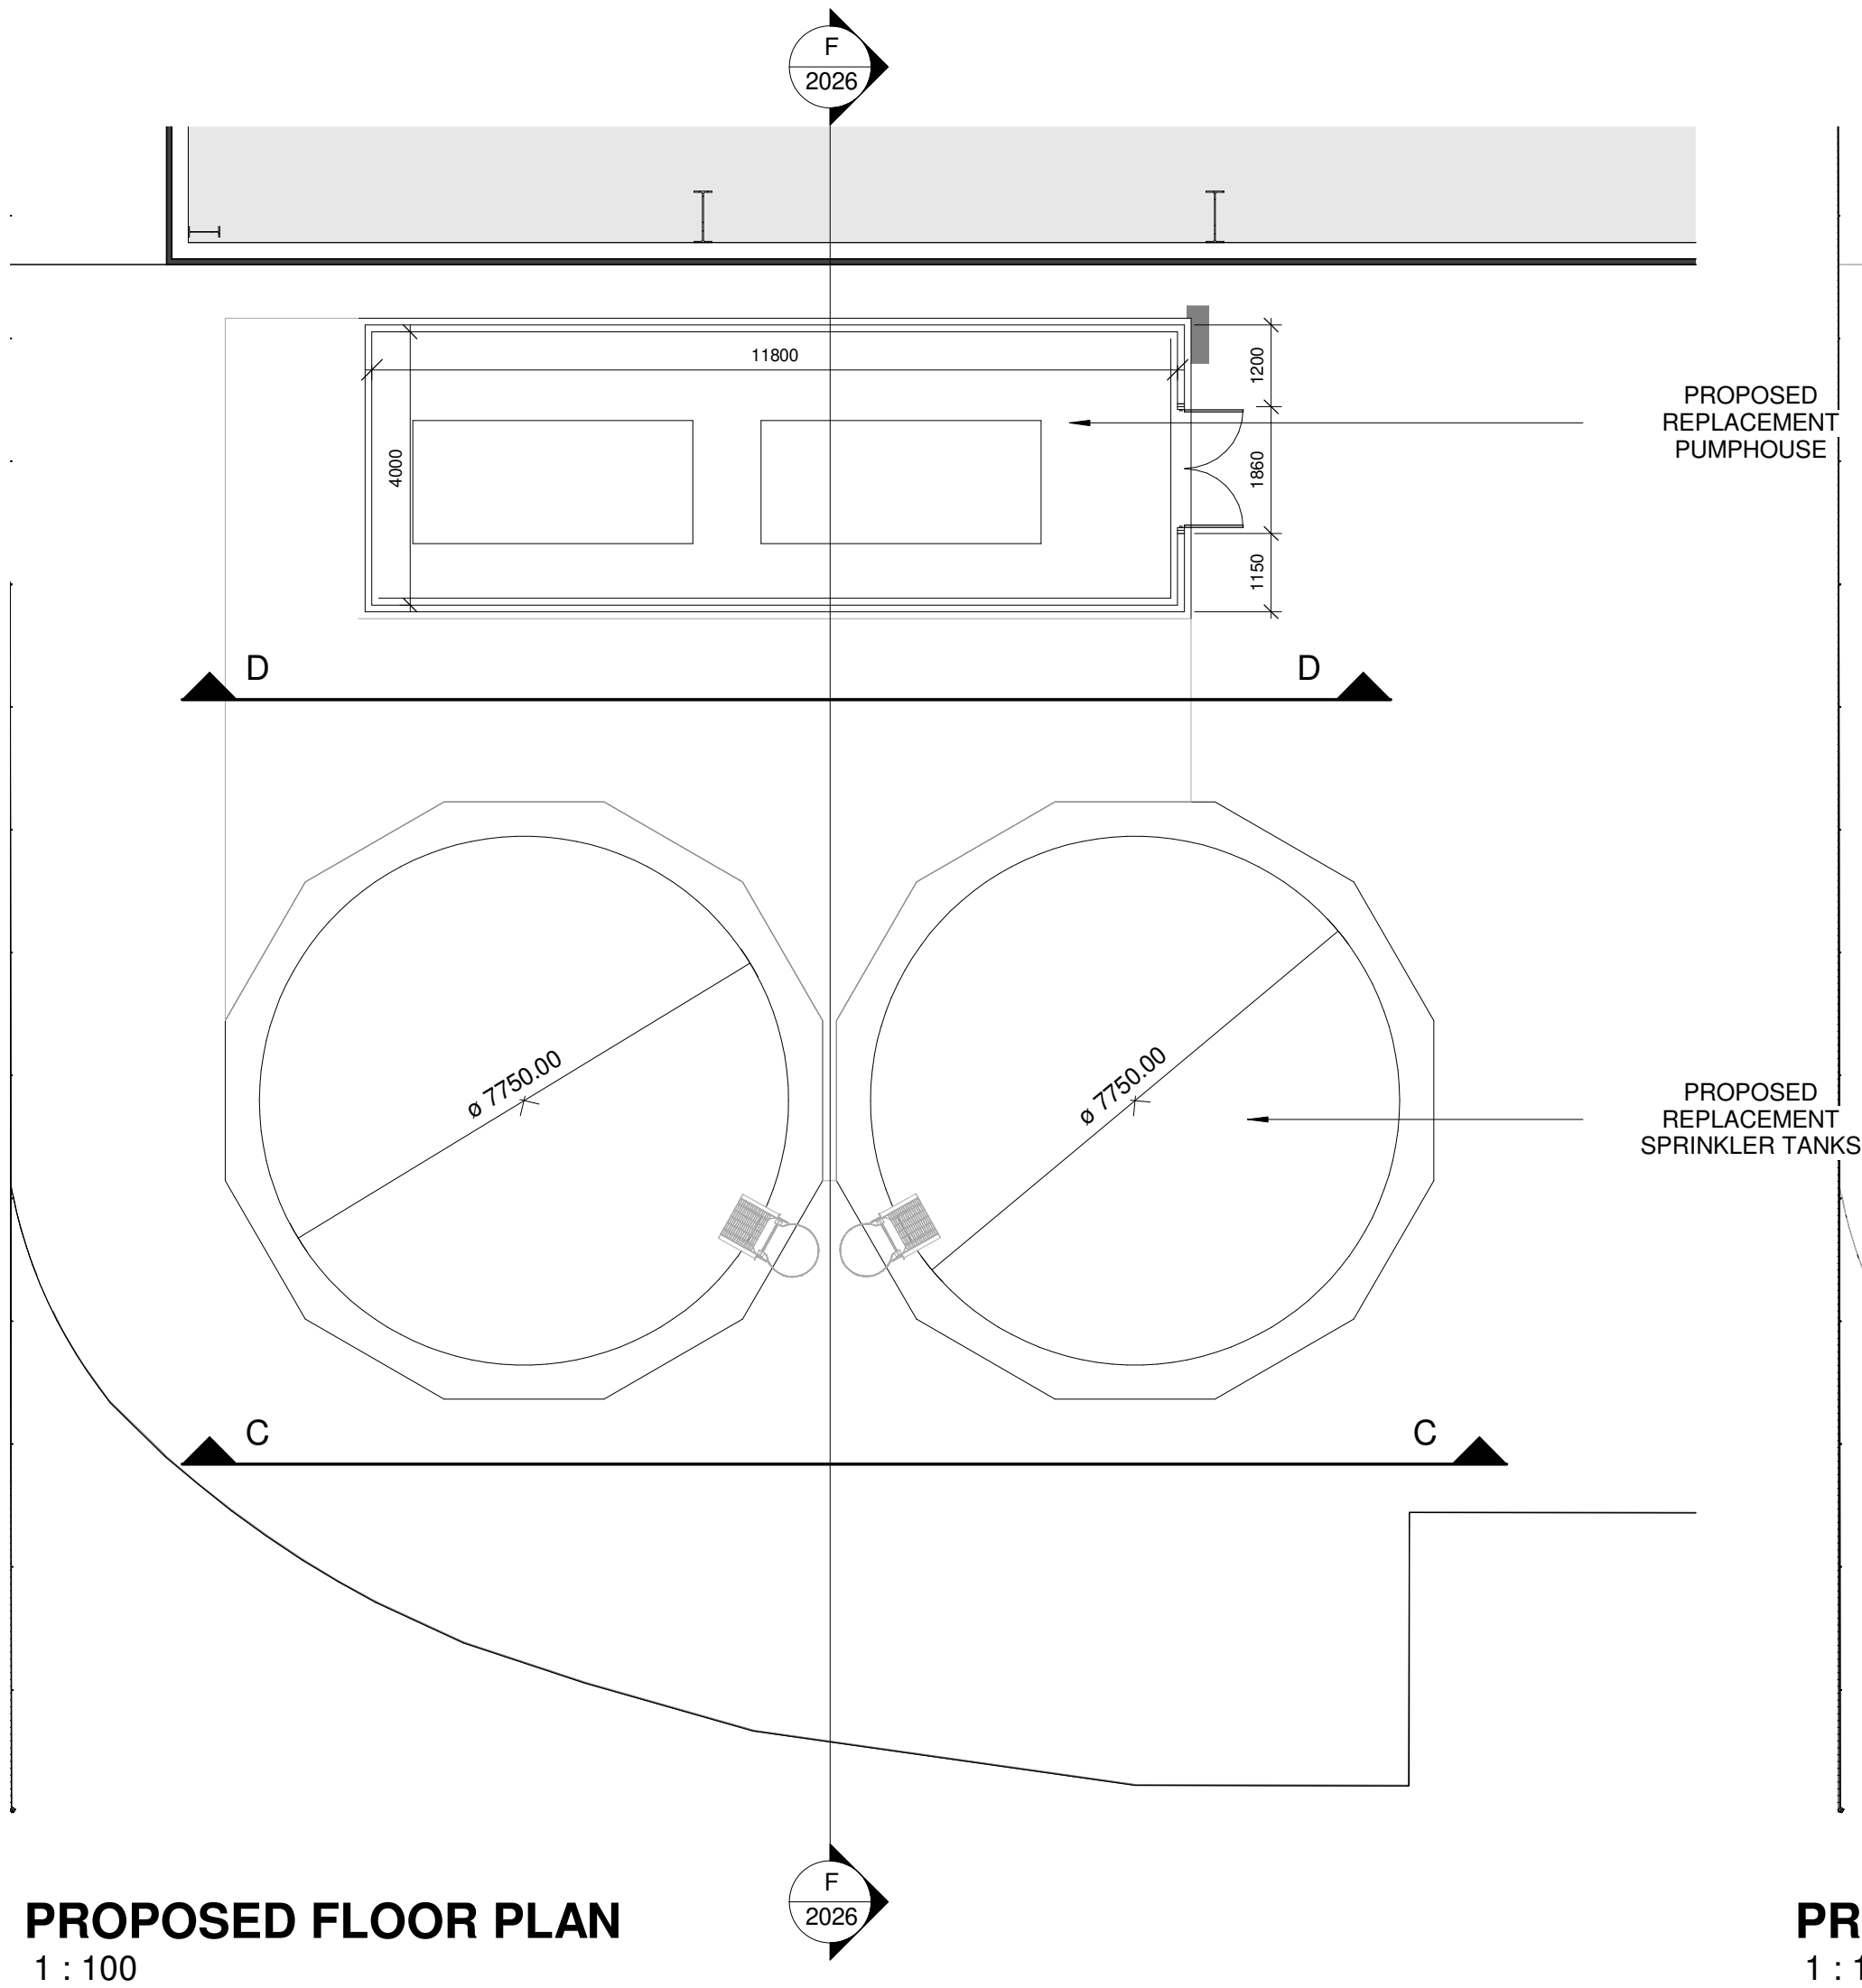


PROPOSED FLOOR PLAN
1 : 100


PROPOSED ROOF PLAN
1 : 100

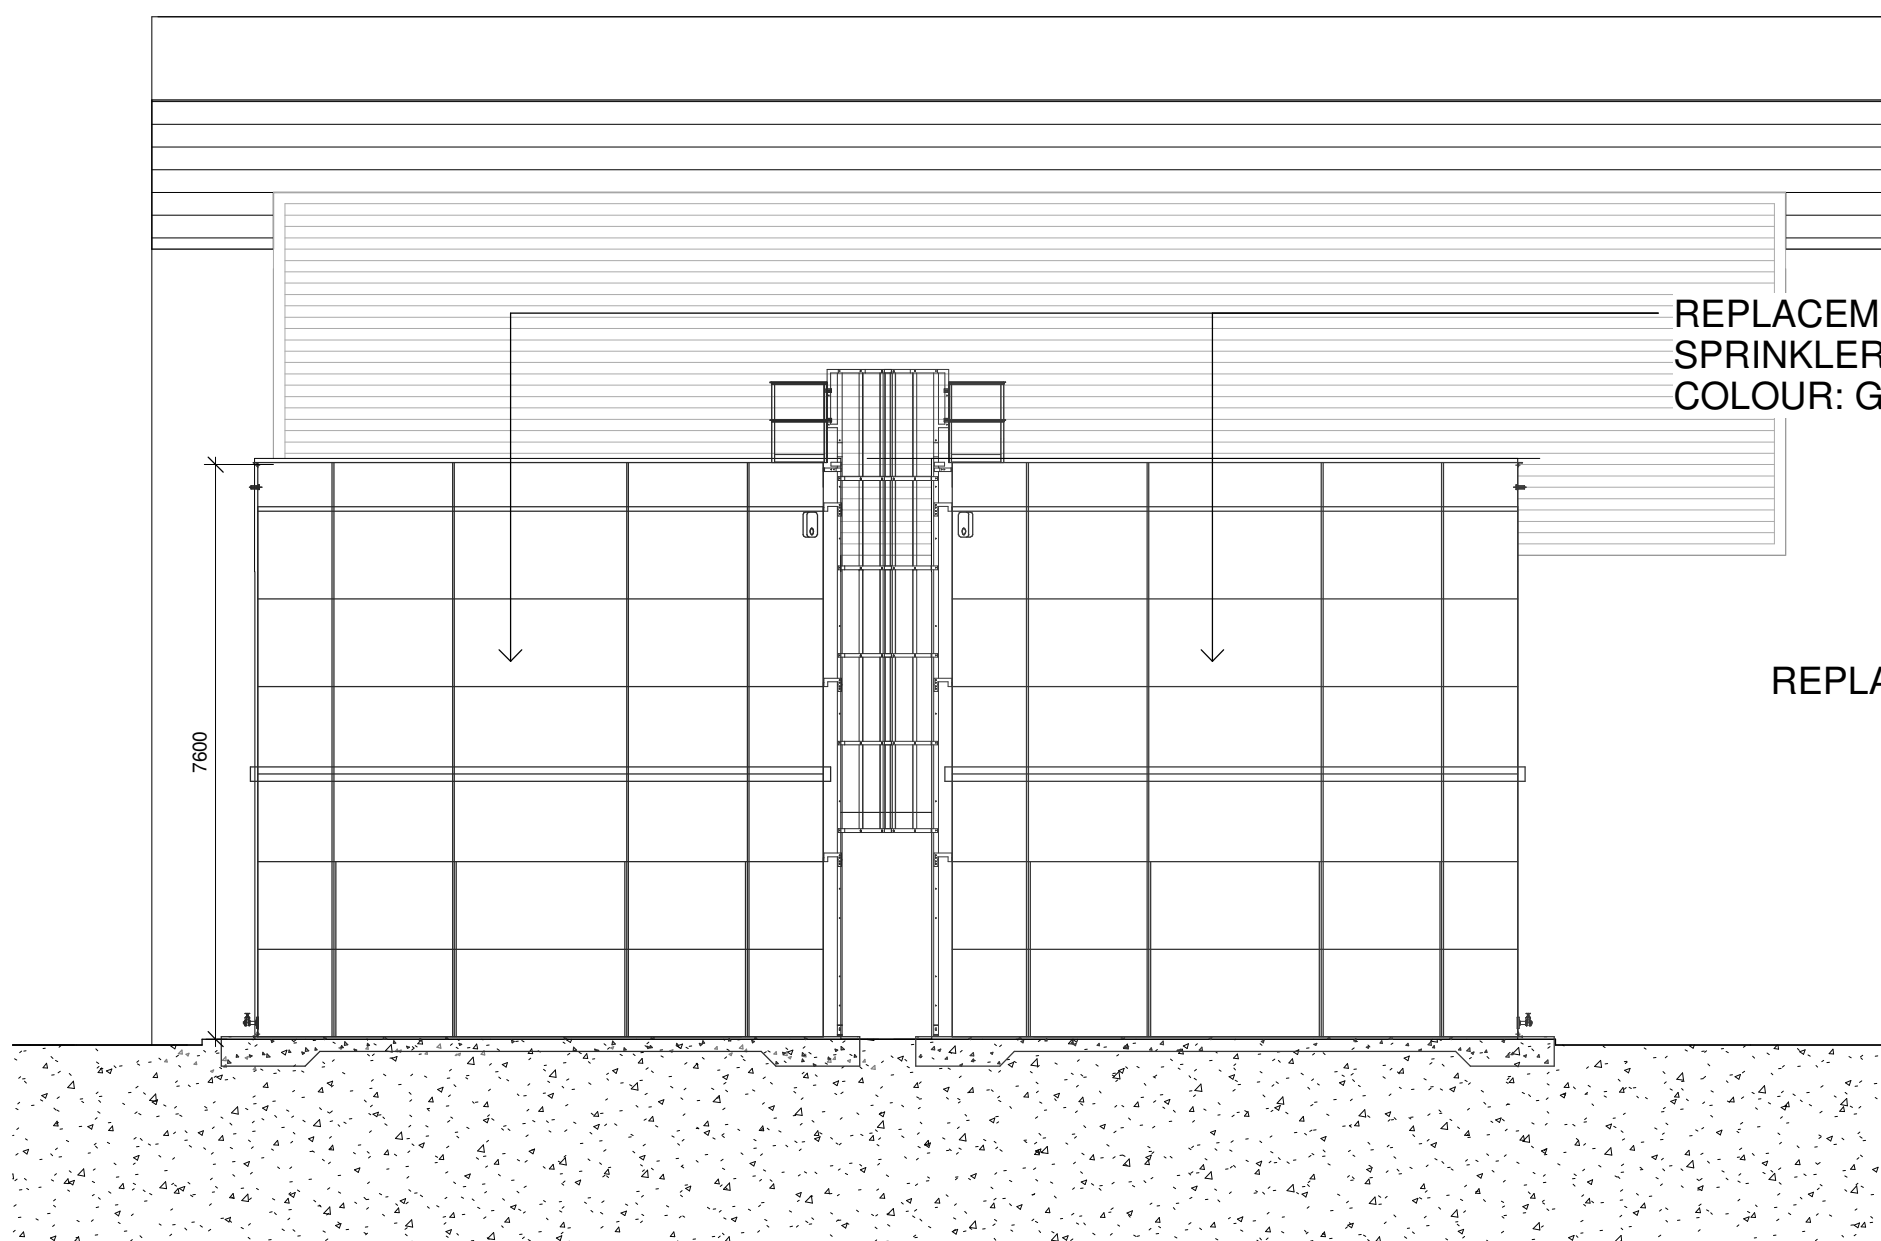

PROPOSED ELEVATION D
1 : 100

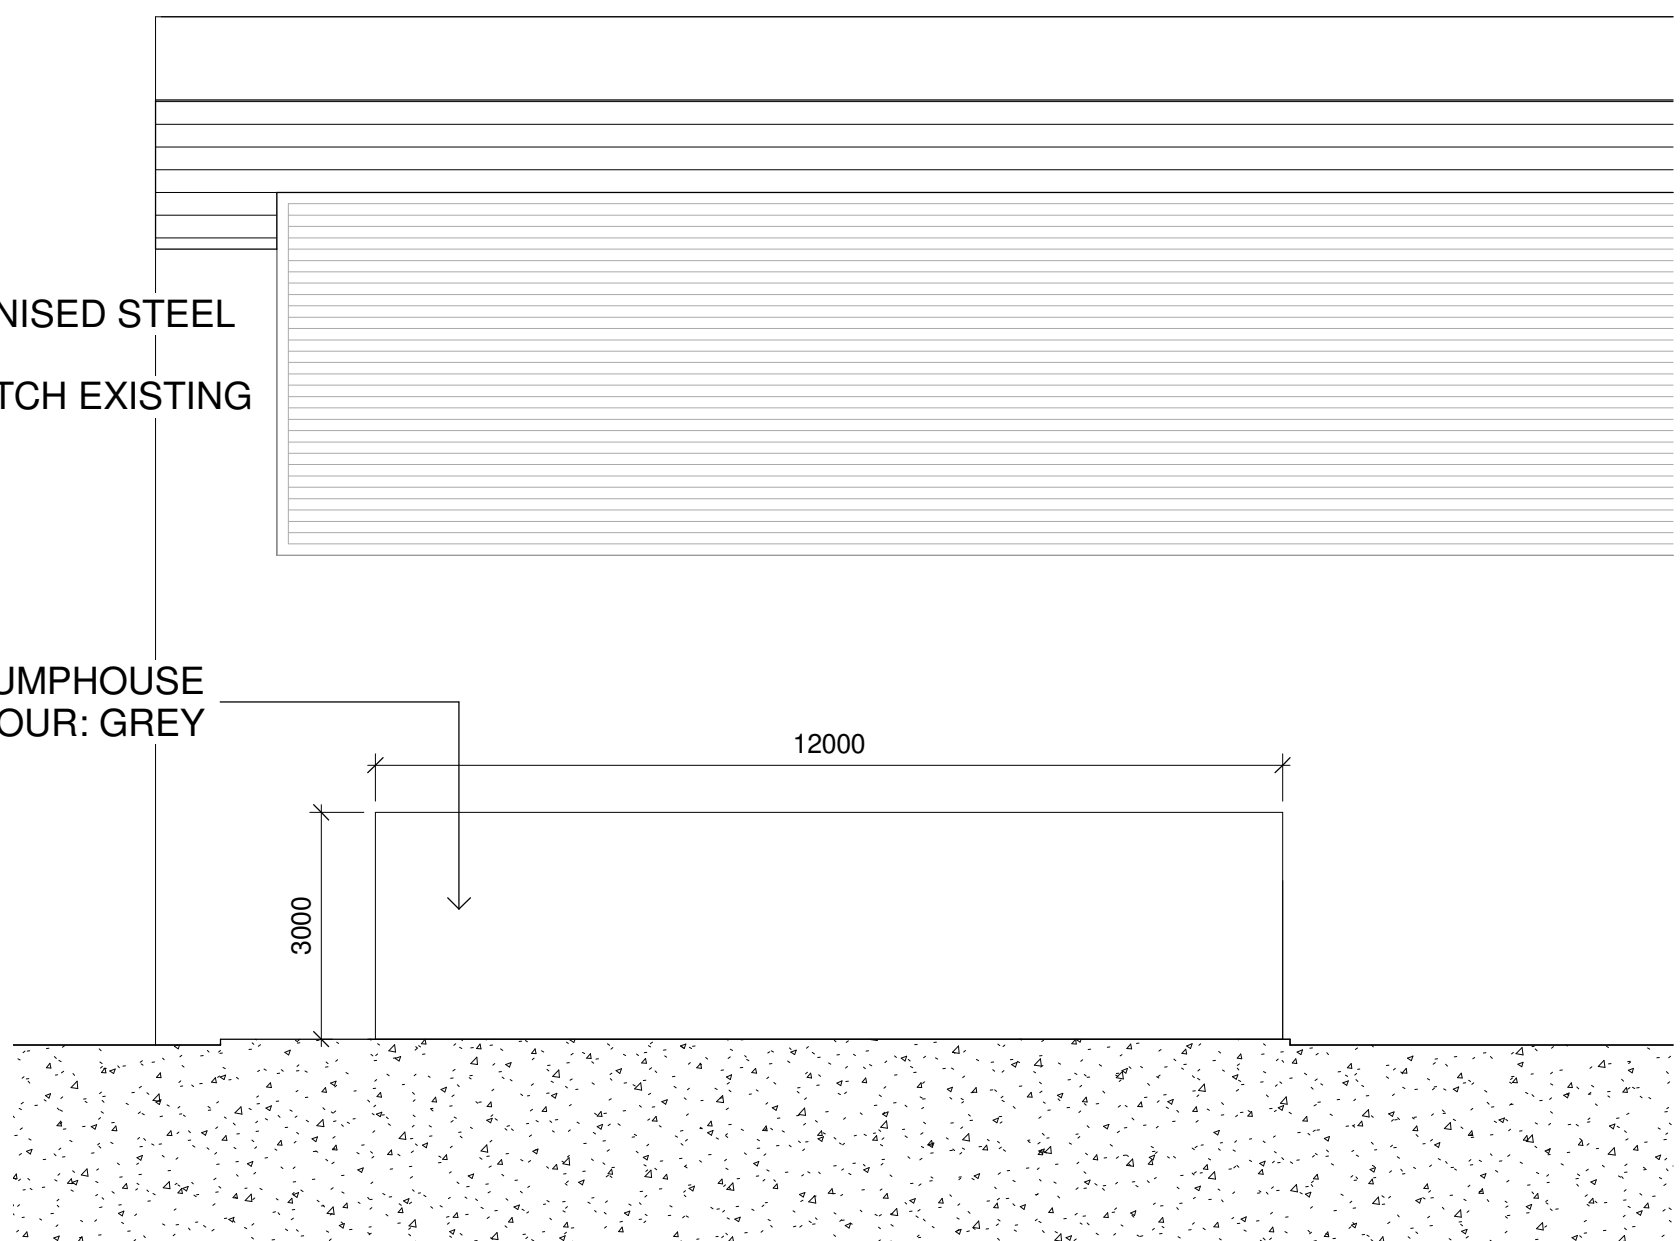

PROPOSED ELEVATION E
1 : 100

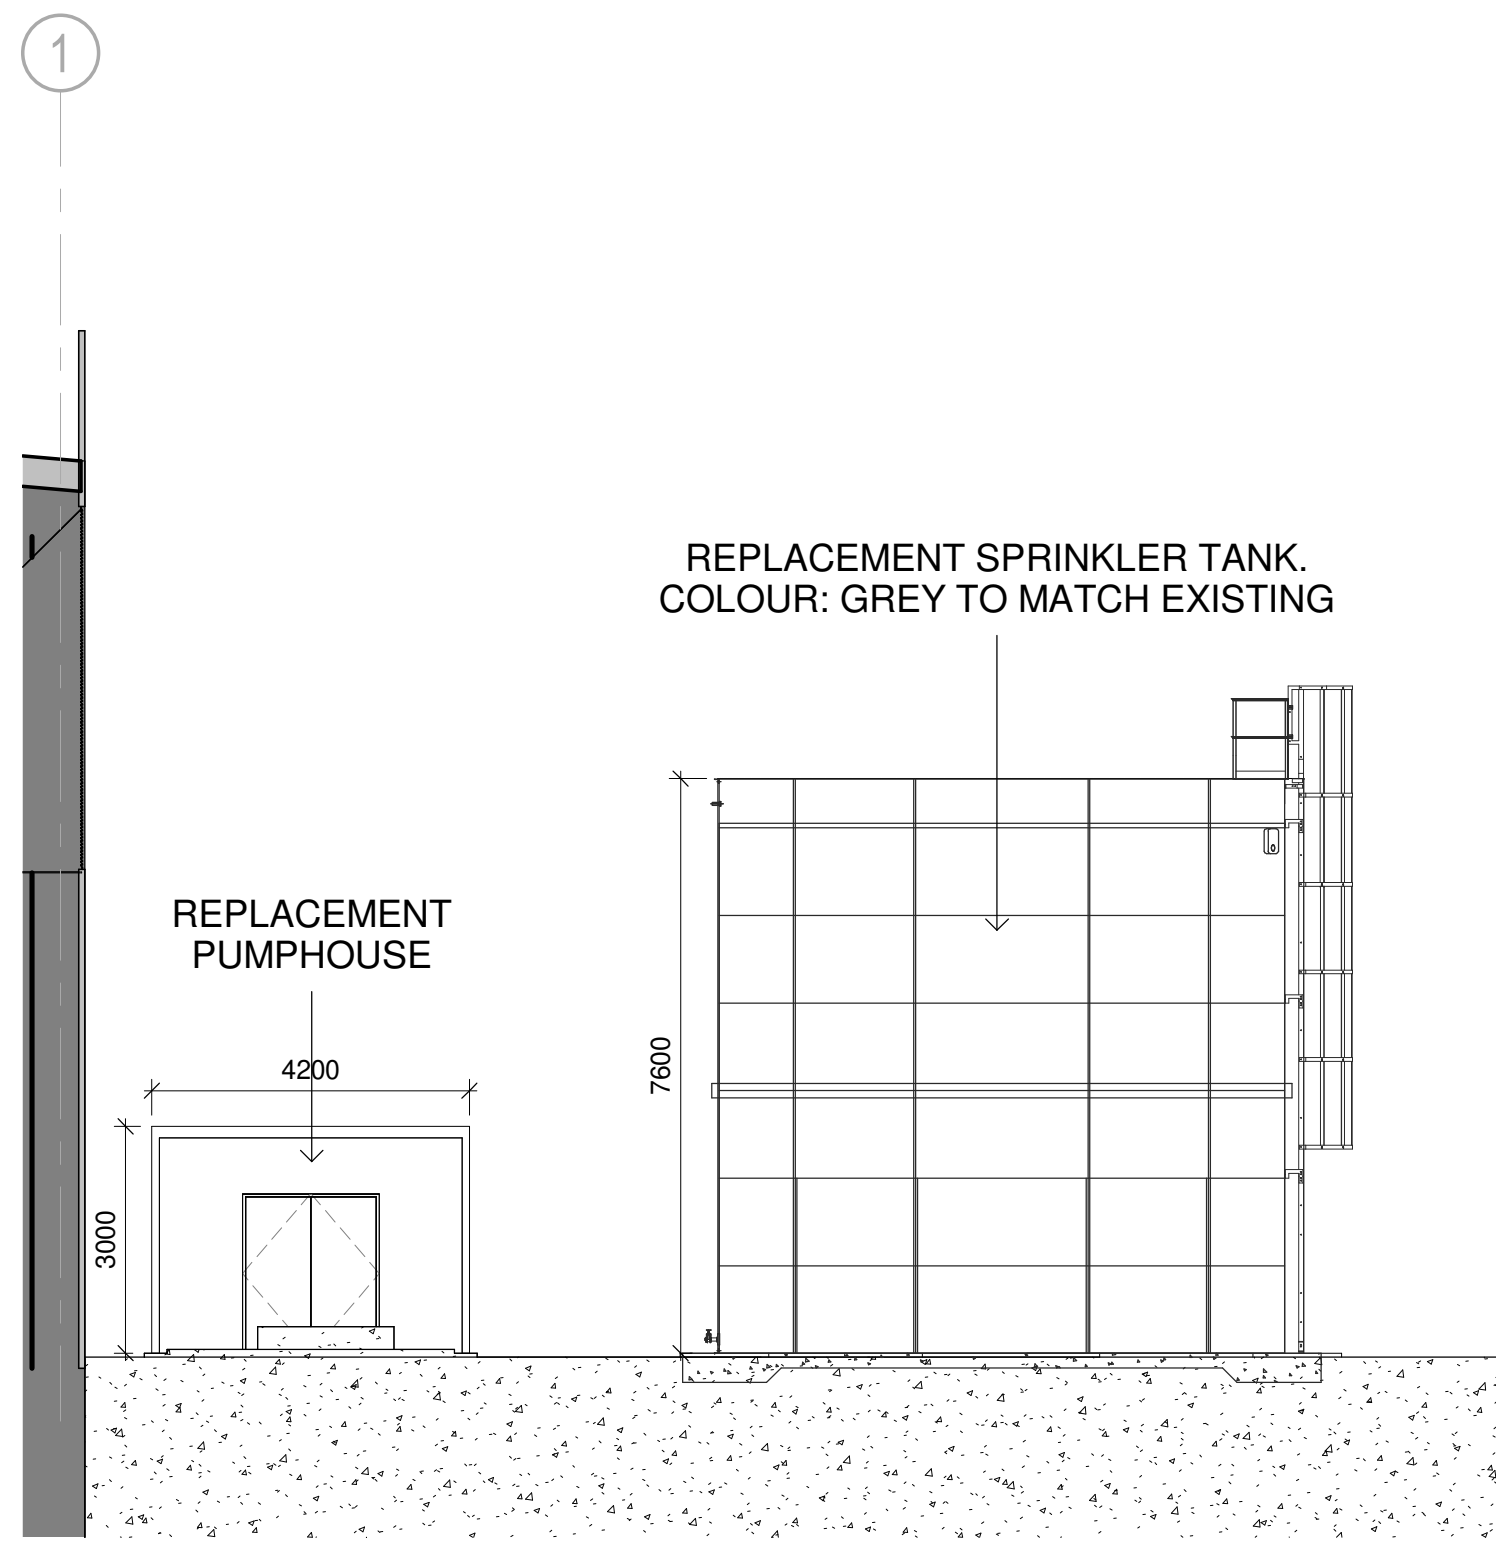

PROPOSED SECTION FF
1 : 100

P1	FIRST ISSUE	13.05.24	VS	-
Rev	Description	Date	Dm	Ckd
Status				
PLANNING				

SMR
SMALLEY MARSEY RISPIN
ARCHITECTS
The Exchange Station Parade Harrogate HG1 1TS
01423 707 757 admin@smrarchitects.co.uk

Project
INTERLINK WAY, COALVILLE

Client
GLEAVE

Drawing Title
PROPOSED REPLACEMENT SPRINKLER TANKS AND
PUMPHOUSE

Proj Ref	Origin	Zone	Level	Type	Role	Num	Status	Rev
7371	- SMR	- 13	- ZZ	- DR	- A	- 2026	- S3	- P1
SMR Job Ref		Sheet		Scale		Drawn		
7371-13-2026		A1		1 : 100		VS		