


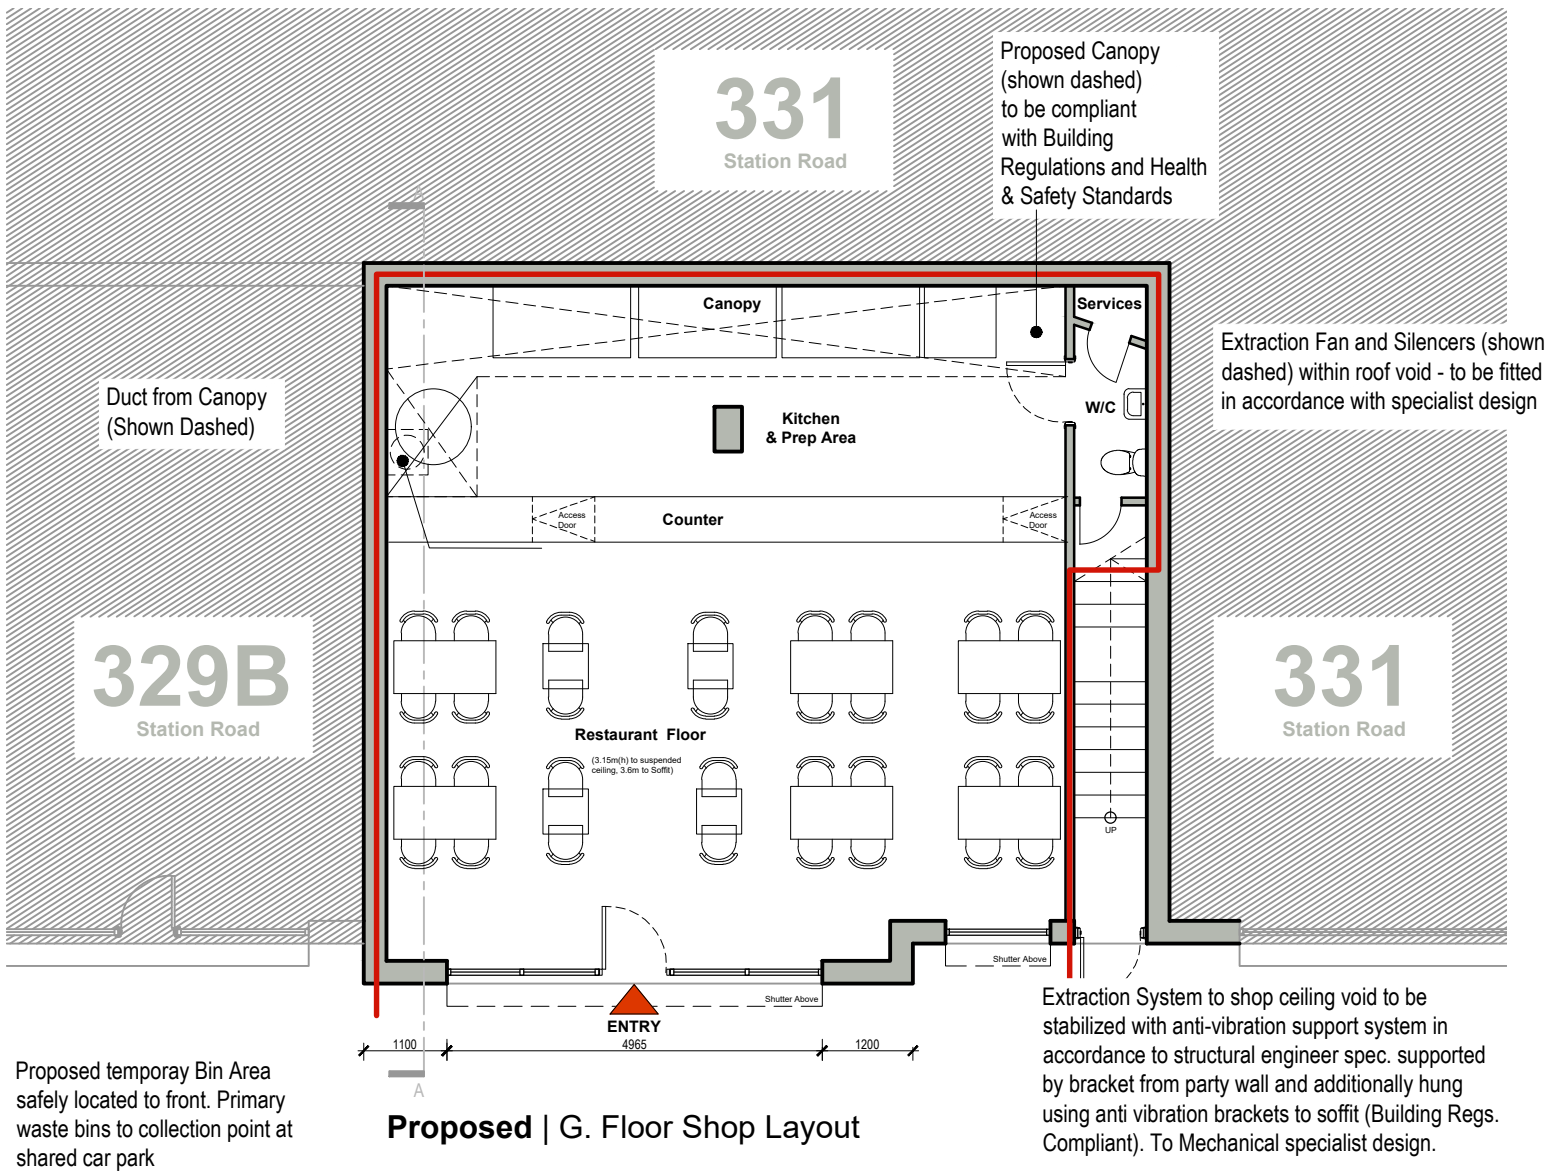


Proposed | G. Floor Shop Layout

Proposed Extraction Flue to rise via existing solid block work chimney stack- 450mm diameter duct.
Duct to be fitted with anti-vibration brackets before install as per ventilation specialist recommendations.

Extraction System to shop ceiling void to be stabilized with anti-vibration support system in accordance to structural engineer spec. supported by bracket from party wall and additionally hung using anti vibration brackets to soffit (Building Regs. Compliant). To Mechanical specialist design.


Ceiling to be insulated with 'Hush Acoustic Sound Absorber' See Acoustic Ceiling Specification

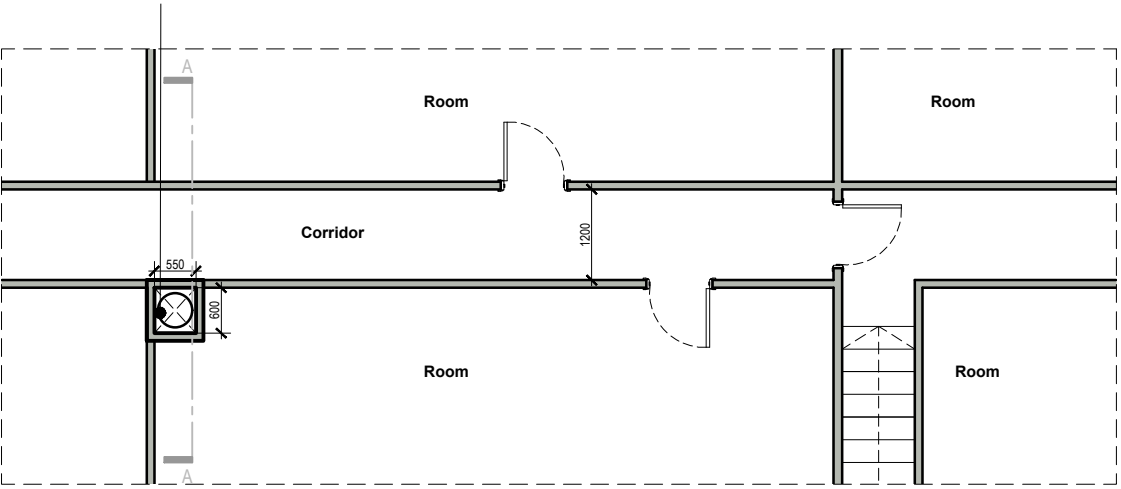

Proposed | First Floor Layout



0 2.5m 5m
SCALE 1:100

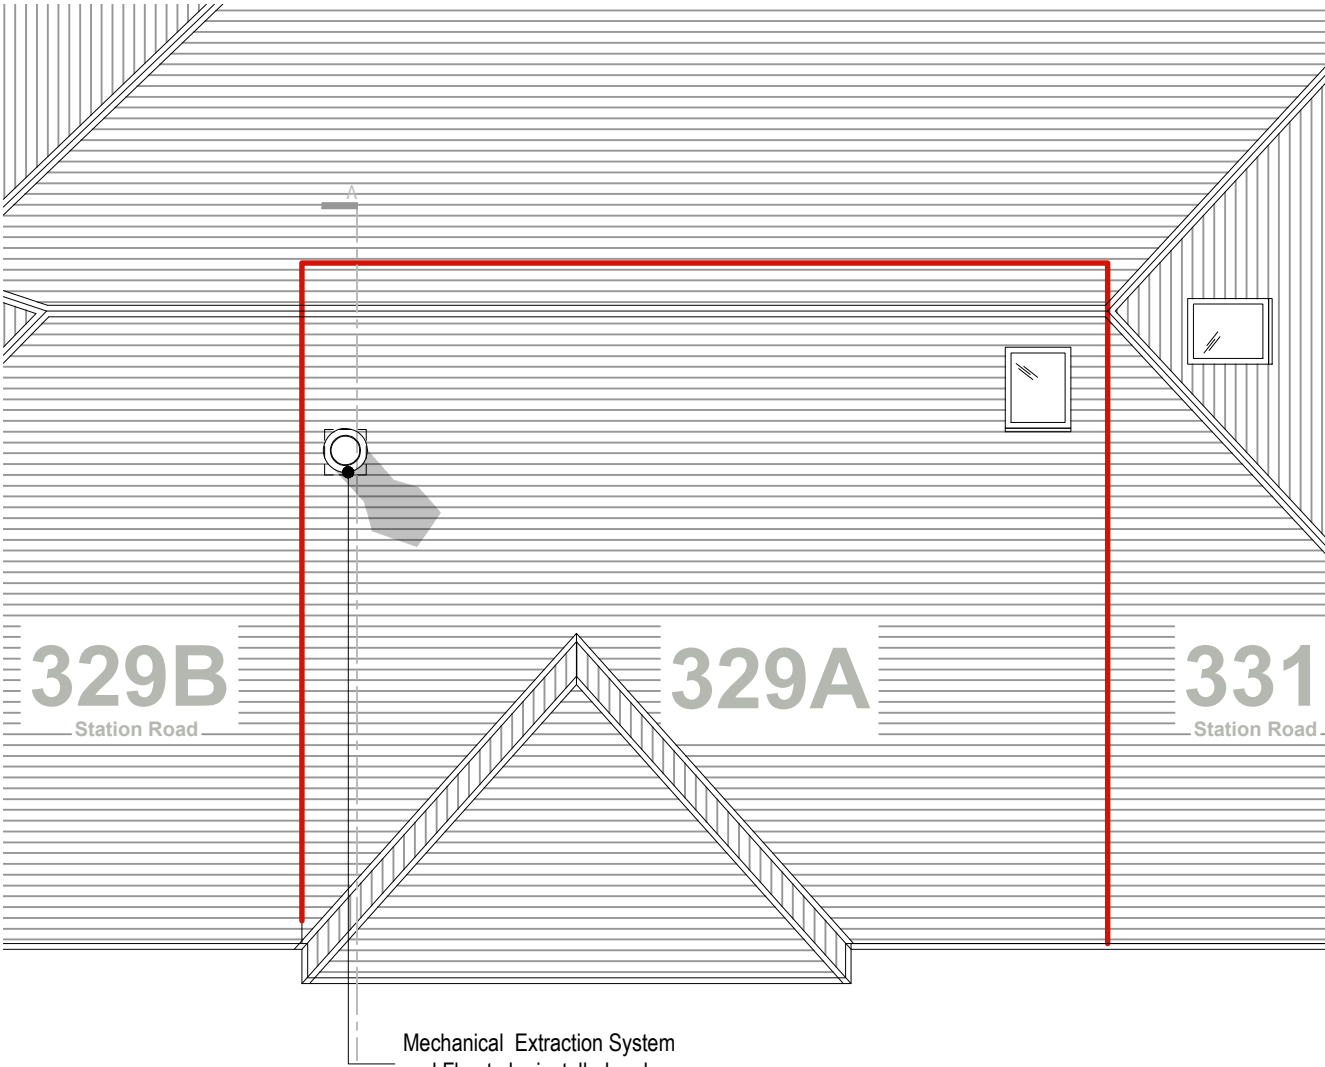

Proposed | Roof Plan

Mechanical Extraction System and Flue to be installed and fitted by a ventilation Specialist - in accordance to manufacturers guidance. Powder Coated in Matte Black

Jet Cowl Flue for maximum diffusion and dispersion of extracted air/steam.
1.0m above Ridge Line
Powder Coated in Matte Black

Key:
Boundary Line

ZEAL WILKES
Architecture Interior Design Planning

a: 81 London Road, Leicester LE2 0PF
e: studio@zealwilkes.co.uk
c: +44 (0)77 6557 6557

Issue Purpose:	PLANNING		
Proposed Restaurant, Installation of Canopy & Flue 329A Station Road, Bagworth LE67 1BL	Drawn by: ZH	Checked by: -	
Proposed GA Plans	Scale @ A3: 1:100	Date: February 2024	
	CAD ref: 2405 001	Dwg no.: 2405/01/300	Rev: -

FIRST ISSUE: 05/02/24 ZH
Rev Date/ Checked

Do not scale. All dimensions in millimeters (mm) - to be confirmed on site.
Information contained in this drawing is the sole copyright of Zeal Wilkes Ltd and is not to be reproduced without permission.