


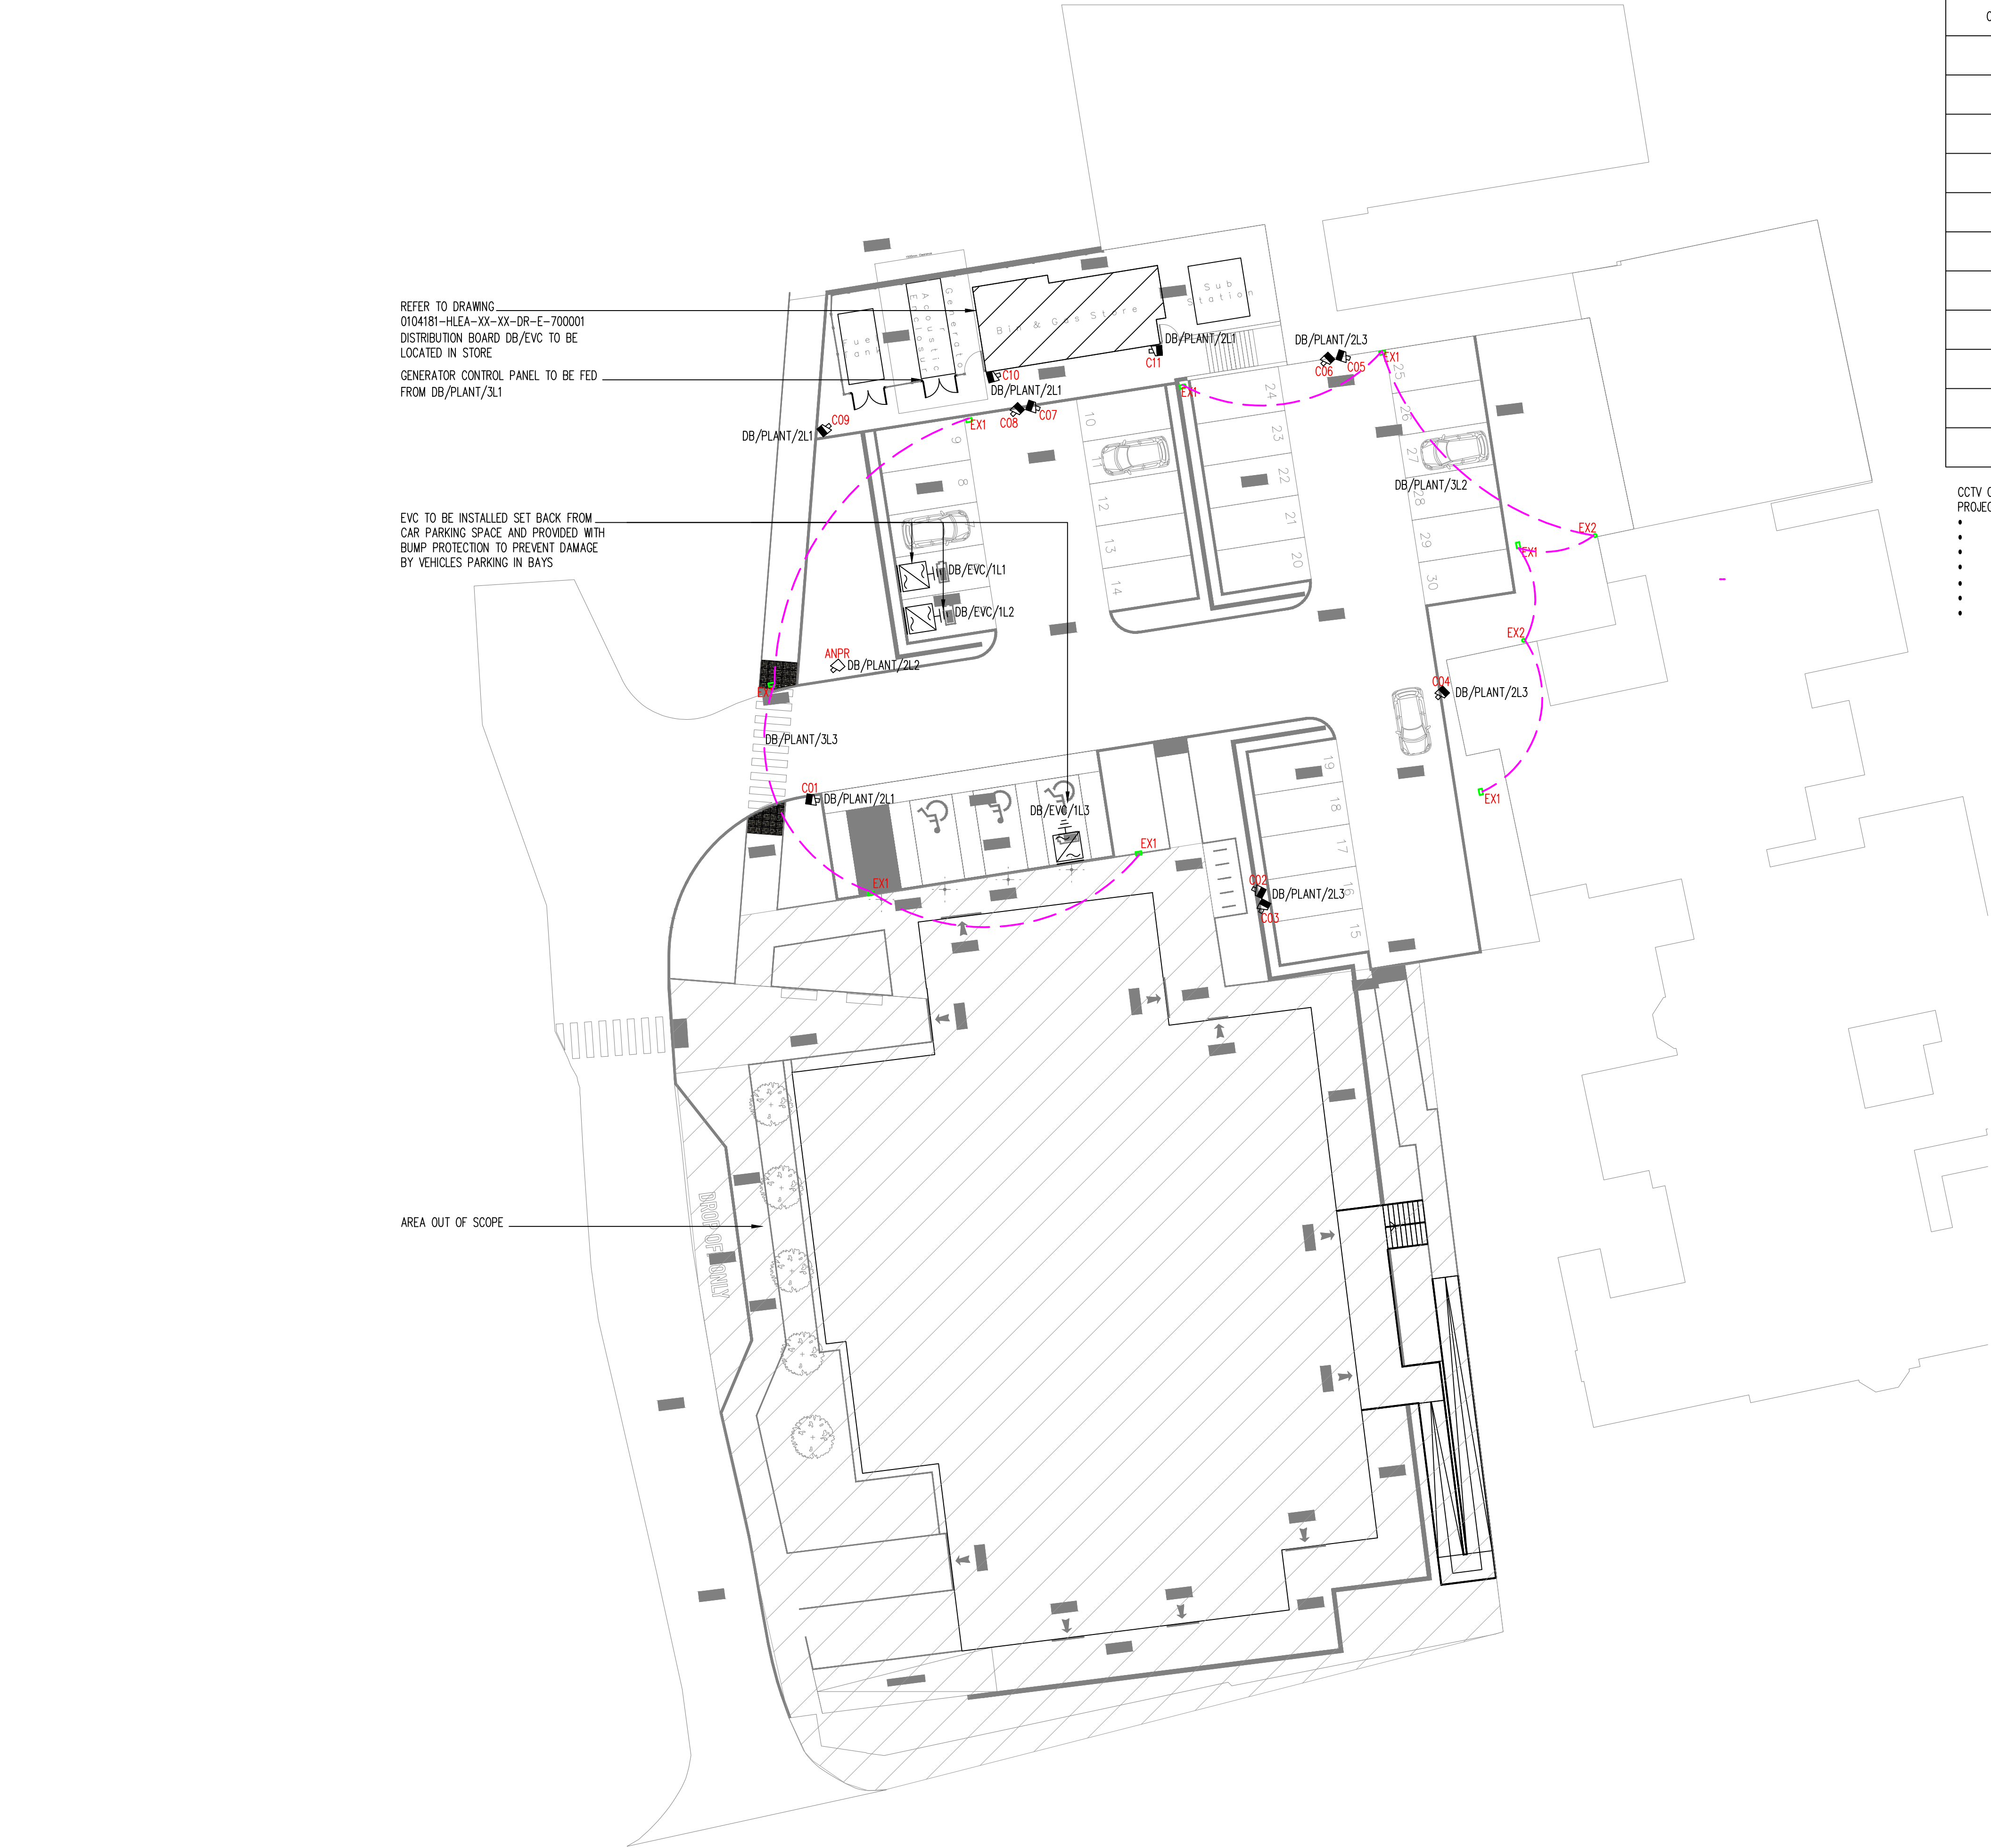

CCTV CAMERA SCHEDULE		
CAMERA REFERENCE	AREA COVERED	CAMERA TYPE
C01	CDC BUILDING ENTRANCE AND ACCESSIBLE PARKING	FIXED
C02	BICYCLE STORE	FIXED
C03	CDC BUILDING ENTRANCE	FIXED
C04	PARKING SPACES 15–19	FIXED
C05	PARKING SPACES 25–30	FIXED
C06	PARKING SPACES 20–24	FIXED
C07	PARKING SPACES 10–14	FIXED
C08	PARKING SPACES 5–9	FIXED
C09	GENERATOR AND FUEL TANK	FIXED
C10	WASTE STORES	FIXED
C11	GAS STORE	FIXED

CCTV CAMERAS HAVE BEEN DETAILED IN ACCORDANCE WITH THE PROJECT SECURITY NEEDS ASSESSMENT TO PROVIDE COVERAGE OF :

- ANPR TO MAIN ENTRANCE
- EACH CAR PARKING SPACE
- ALL BUILDING ENTRANCES
- ALL EMERGENCY EXIT DOORS
- BIN/MEDICAL STORE
- MEDICAL GAS STORE
- EXTERNAL CYCLE STANDS

CDM Regulations:
In addition to any information included in this drawing or the model from which it is derived, refer also to the project CDM Risk Register for information on residual risks.

- General Notes:
- The drawing does not necessarily show all the information needed to interpret the design intent or the construction details.
 - The drawing contains information from more than one source and must be read in conjunction with all relevant specifications.
 - Any apparent drafting errors and differences between other drawings and specifications shall be brought to our attention.

- Project Notes:
1. FOR CIRCUIT DETAILS REFER TO THE DISTRIBUTION BOARD SCHEDULE
 2. INSTALLATION TO BE COMPLIANT WITH BS 7671:2018 +A2:2022
 3. CIRCUIT DETAILS, INCLUDING CABLE SIZES ASSOCIATED WITH THE DESIGN ARE BASED ON ASSUMED UPSTREAM CONDITIONS (CDC BUILDING DESIGN BY OTHERS) AND THEREFORE ARE SUBJECT TO VERIFICATION IN THE FINAL CALCULATIONS.
 4. CCTV REQUIREMENTS ARE SUBJECT TO REVIEW BY TRUST.
 5. CIRCUITS TO EXTERNAL LIGHTING AND CCTV CAMERAS TO BE FED FROM CDC BUILDING (BY OTHERS).
 6. FOR DUCTING LAYOUT REFER TO DRAWING 0104181-HLEA-XX-XX-DR-CS-100101

LEGEND:

-  EX1 HOLOPHANE D-SERIES O AREA LUMINAIRE. 21W, 3030 lm OR EQUAL AND APPROVED. COLUMN MOUNTED AT 5m.
-  EX2 THORLUX PASSWAY PATHWAY BOLLARD LUMINAIRE. 11W, 780 lm OR EQUAL AND APPROVED.
-  EXTERNAL CCTV CAMERA
-  ANPR EXTERNAL AUTOMATIC NUMBER PLATE RECOGNITION CAMERA
-  7kW SPN ELECTRIC VEHICLE CHARGER WITH LOCAL EARTH ELECTRODE

PO1 STAGE 4 ISSUE JH MAB CS MAR'24

REVISIONS:

HOARE LEA 

ARCHITECT:
THE DESIGN BURO

CLIENT:
NHS PROPERTY SERVICES

PROJECT TITLE:
HINCKLEY CDC & ENDOSCOPY

DRAWING TITLE:
Hinckley CDC Enabling Works
Electrical Services
External Layout

STAGE 4

PERSON RESPONSIBLE FOR:		
Design: JH	Review: MAB	Authorising Issue: CS

Project No: 0104181	Date: MARCH 2024	Scale @ A1: 1:200
------------------------	---------------------	----------------------

DRAWING NUMBER:		Status:	Rev:
0104181-HLEA-XX-XX-DR-E-708001		S2	P01

EXTERNAL REFERENCES DRG No's
20240221 - DBS1782-08C-ENB-00-DR-A-0050 P03 Proposed Site Plan