


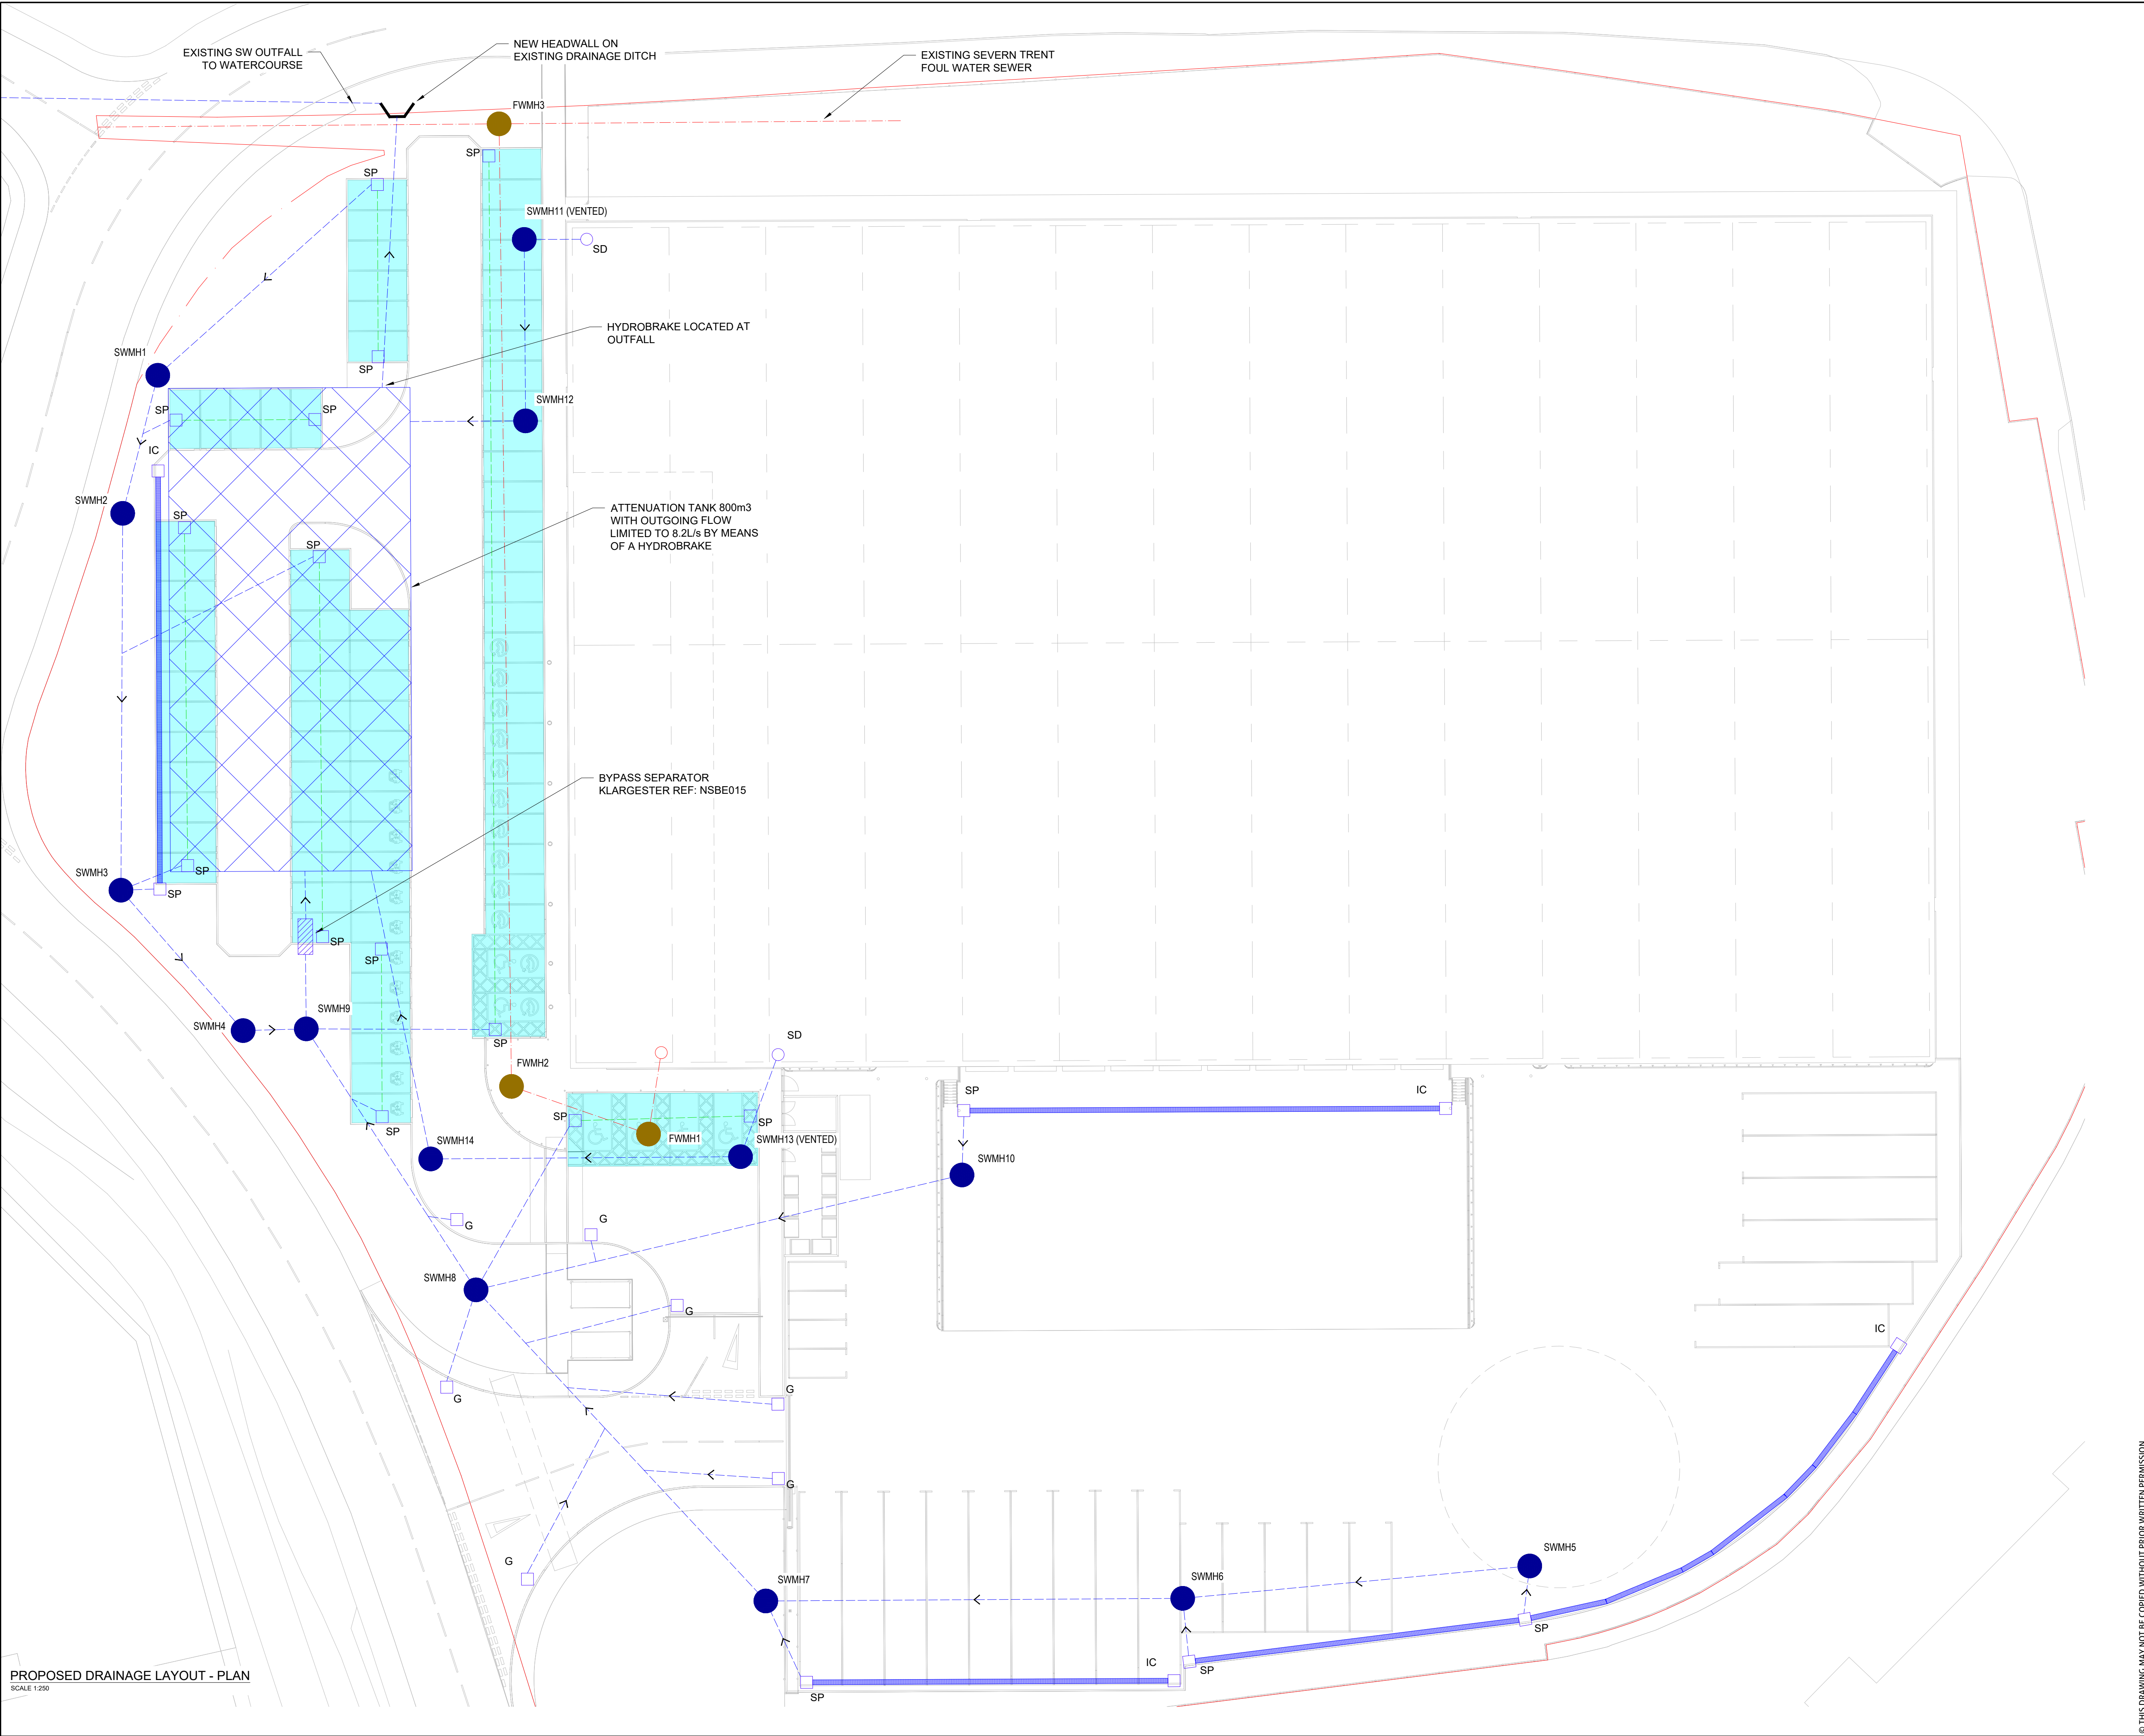

DESIGNER RISK INFORMATION

IN ADDITION TO THE HAZARDS/RISKS NORMALLY ASSOCIATED WITH THE TYPES OF WORK DETAILED ON THIS DRAWING, NOTE THE FOLLOWING:-

CONSTRUCTION:

MAINTENANCE/CLEANING:

DECOMMISSIONING/DEMOLITION:

IT IS ASSUMED THAT ALL WORKS WILL BE CARRIED OUT BY A COMPETENT CONTRACTOR WORKING, WHERE APPROPRIATE, TO AN APPROVED METHOD STATEMENT.

LEGEND

SP

SILT PIT

IC

INSPECTION CHAMBER

G

ROAD GULLY

SD

SYPHONIC DOWNPIPE

SURFACE WATER MANHOLE

SURFACE WATER PIPE

FOUL WATER MANHOLE

FOUL WATER PIPE

DRAINAGE CHANNEL

PERFORATED PIPE

POROUS PAVING

PROPOSED DRAINAGE LAYOUT - PLAN

SCALE 1:250

PO209.02.26DRAINAGE LAYOUT AMENDED

EH

APD

PO128.10.25FIRST ISSUE

EH

APD

Rev

Date

Amendment

mjm

Consulting Engineers Ltd

Southgate House, 38 Southgate, Wakefield WF1 1TL

T: 01924 811 000

mjm.co.uk

Project:

GRAFTONGATE, HINCKLEY

Client:

GRAFTONGATE

Drawing Title:

PROPOSED DRAINAGE LAYOUT

EH

APD

APD

MJMC Ref:

25109

Scale:

1:250

Sheet Size:

A1

Revision Status:

PO2

Suitability Status:

S2

Date:

OCT 25

Suitability Description:

INFORMATION

Drawing Reference:

Project - Originator - Zone - Level - File Type - Discipline - Number

25109 - MJM - 00 - 00 - DR - C - 5200

© THIS DRAWING MAY NOT BE COPIED WITHOUT PRIOR WRITTEN PERMISSION