


|      |              |     |       |
|------|--------------|-----|-------|
| Rev: | Description: | By: | Date: |
|------|--------------|-----|-------|

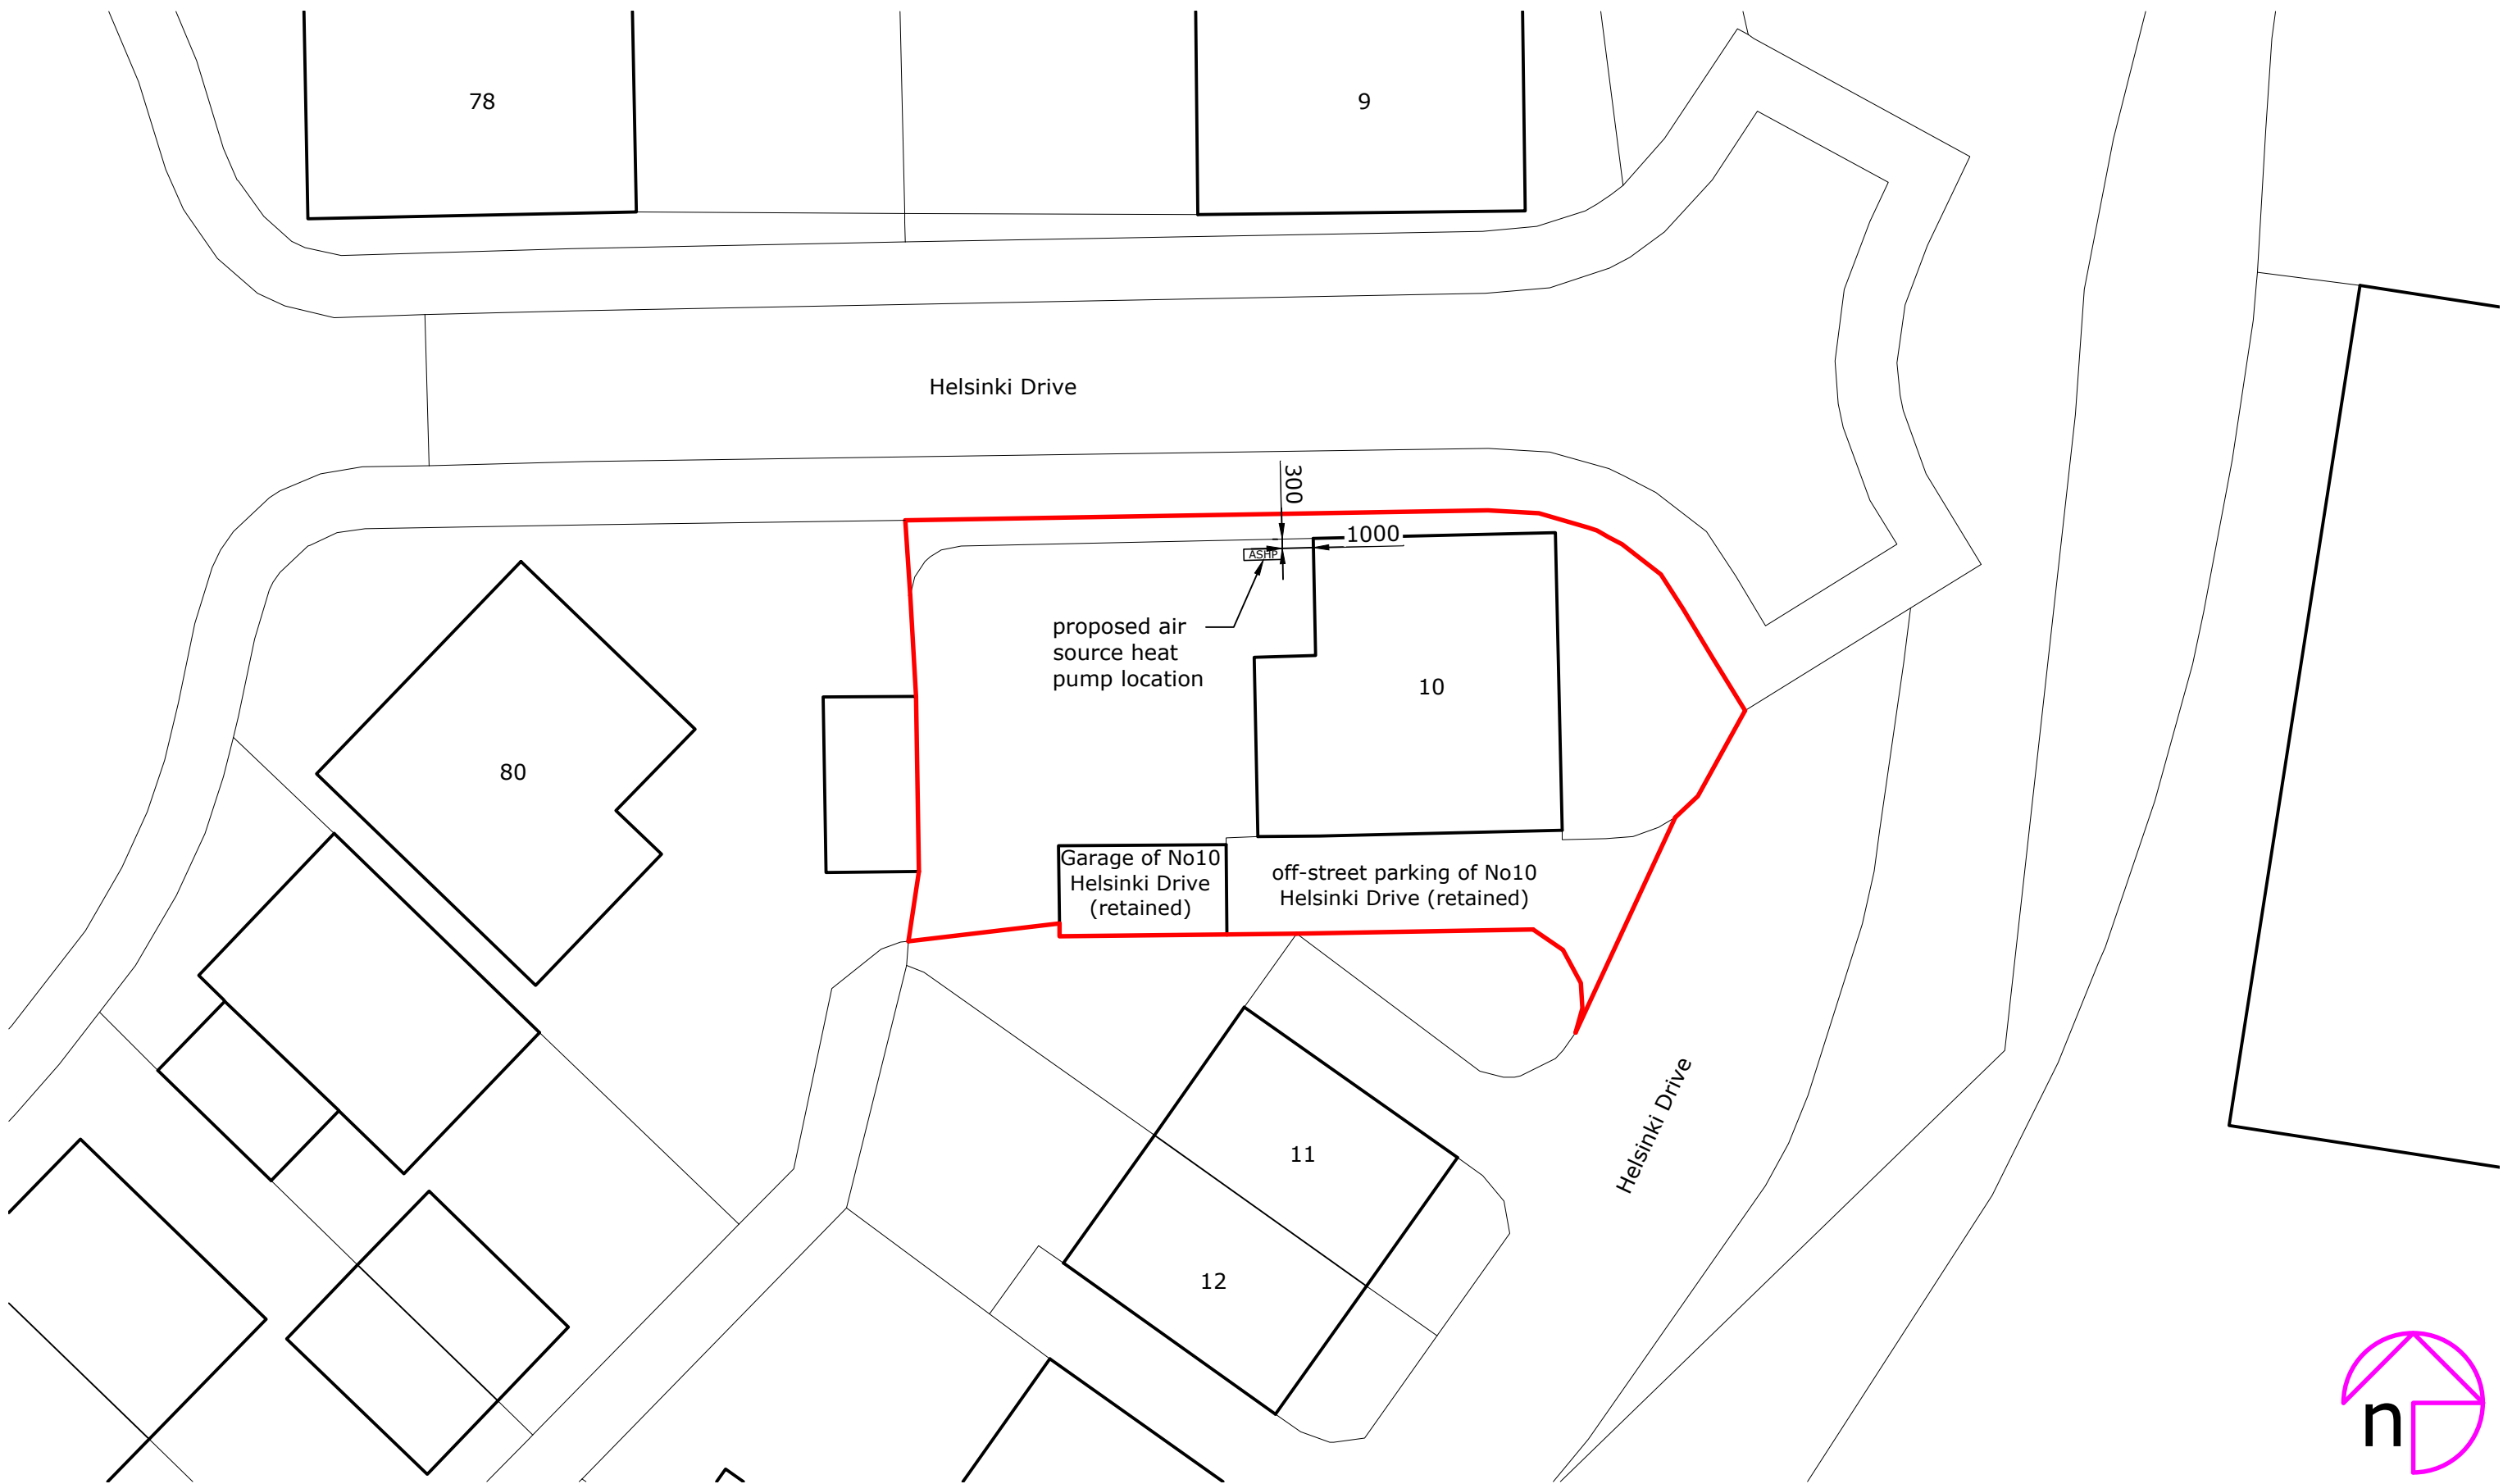

octopusenergy  
services

Approved by:



|                                                                               |                                                                                                               |
|-------------------------------------------------------------------------------|---------------------------------------------------------------------------------------------------------------|
| Client/Project:<br>Andrew Baird,<br>10, Helsinki Drive,<br>Hinckley, LE10 1FN | Project status:<br>PLANNING (installation of air source heat pump)<br>Drawing title:<br>Site plan as proposed |
|-------------------------------------------------------------------------------|---------------------------------------------------------------------------------------------------------------|

|                           |                   |                    |                     |
|---------------------------|-------------------|--------------------|---------------------|
| Scale:<br>1:200           | Paper Size:<br>A3 | Drawn:<br>A Walton | Checked:<br>...     |
| Project ID:<br>J-B5752780 | Drawing No:<br>03 | Revision:          | Date:<br>11.04.2025 |