


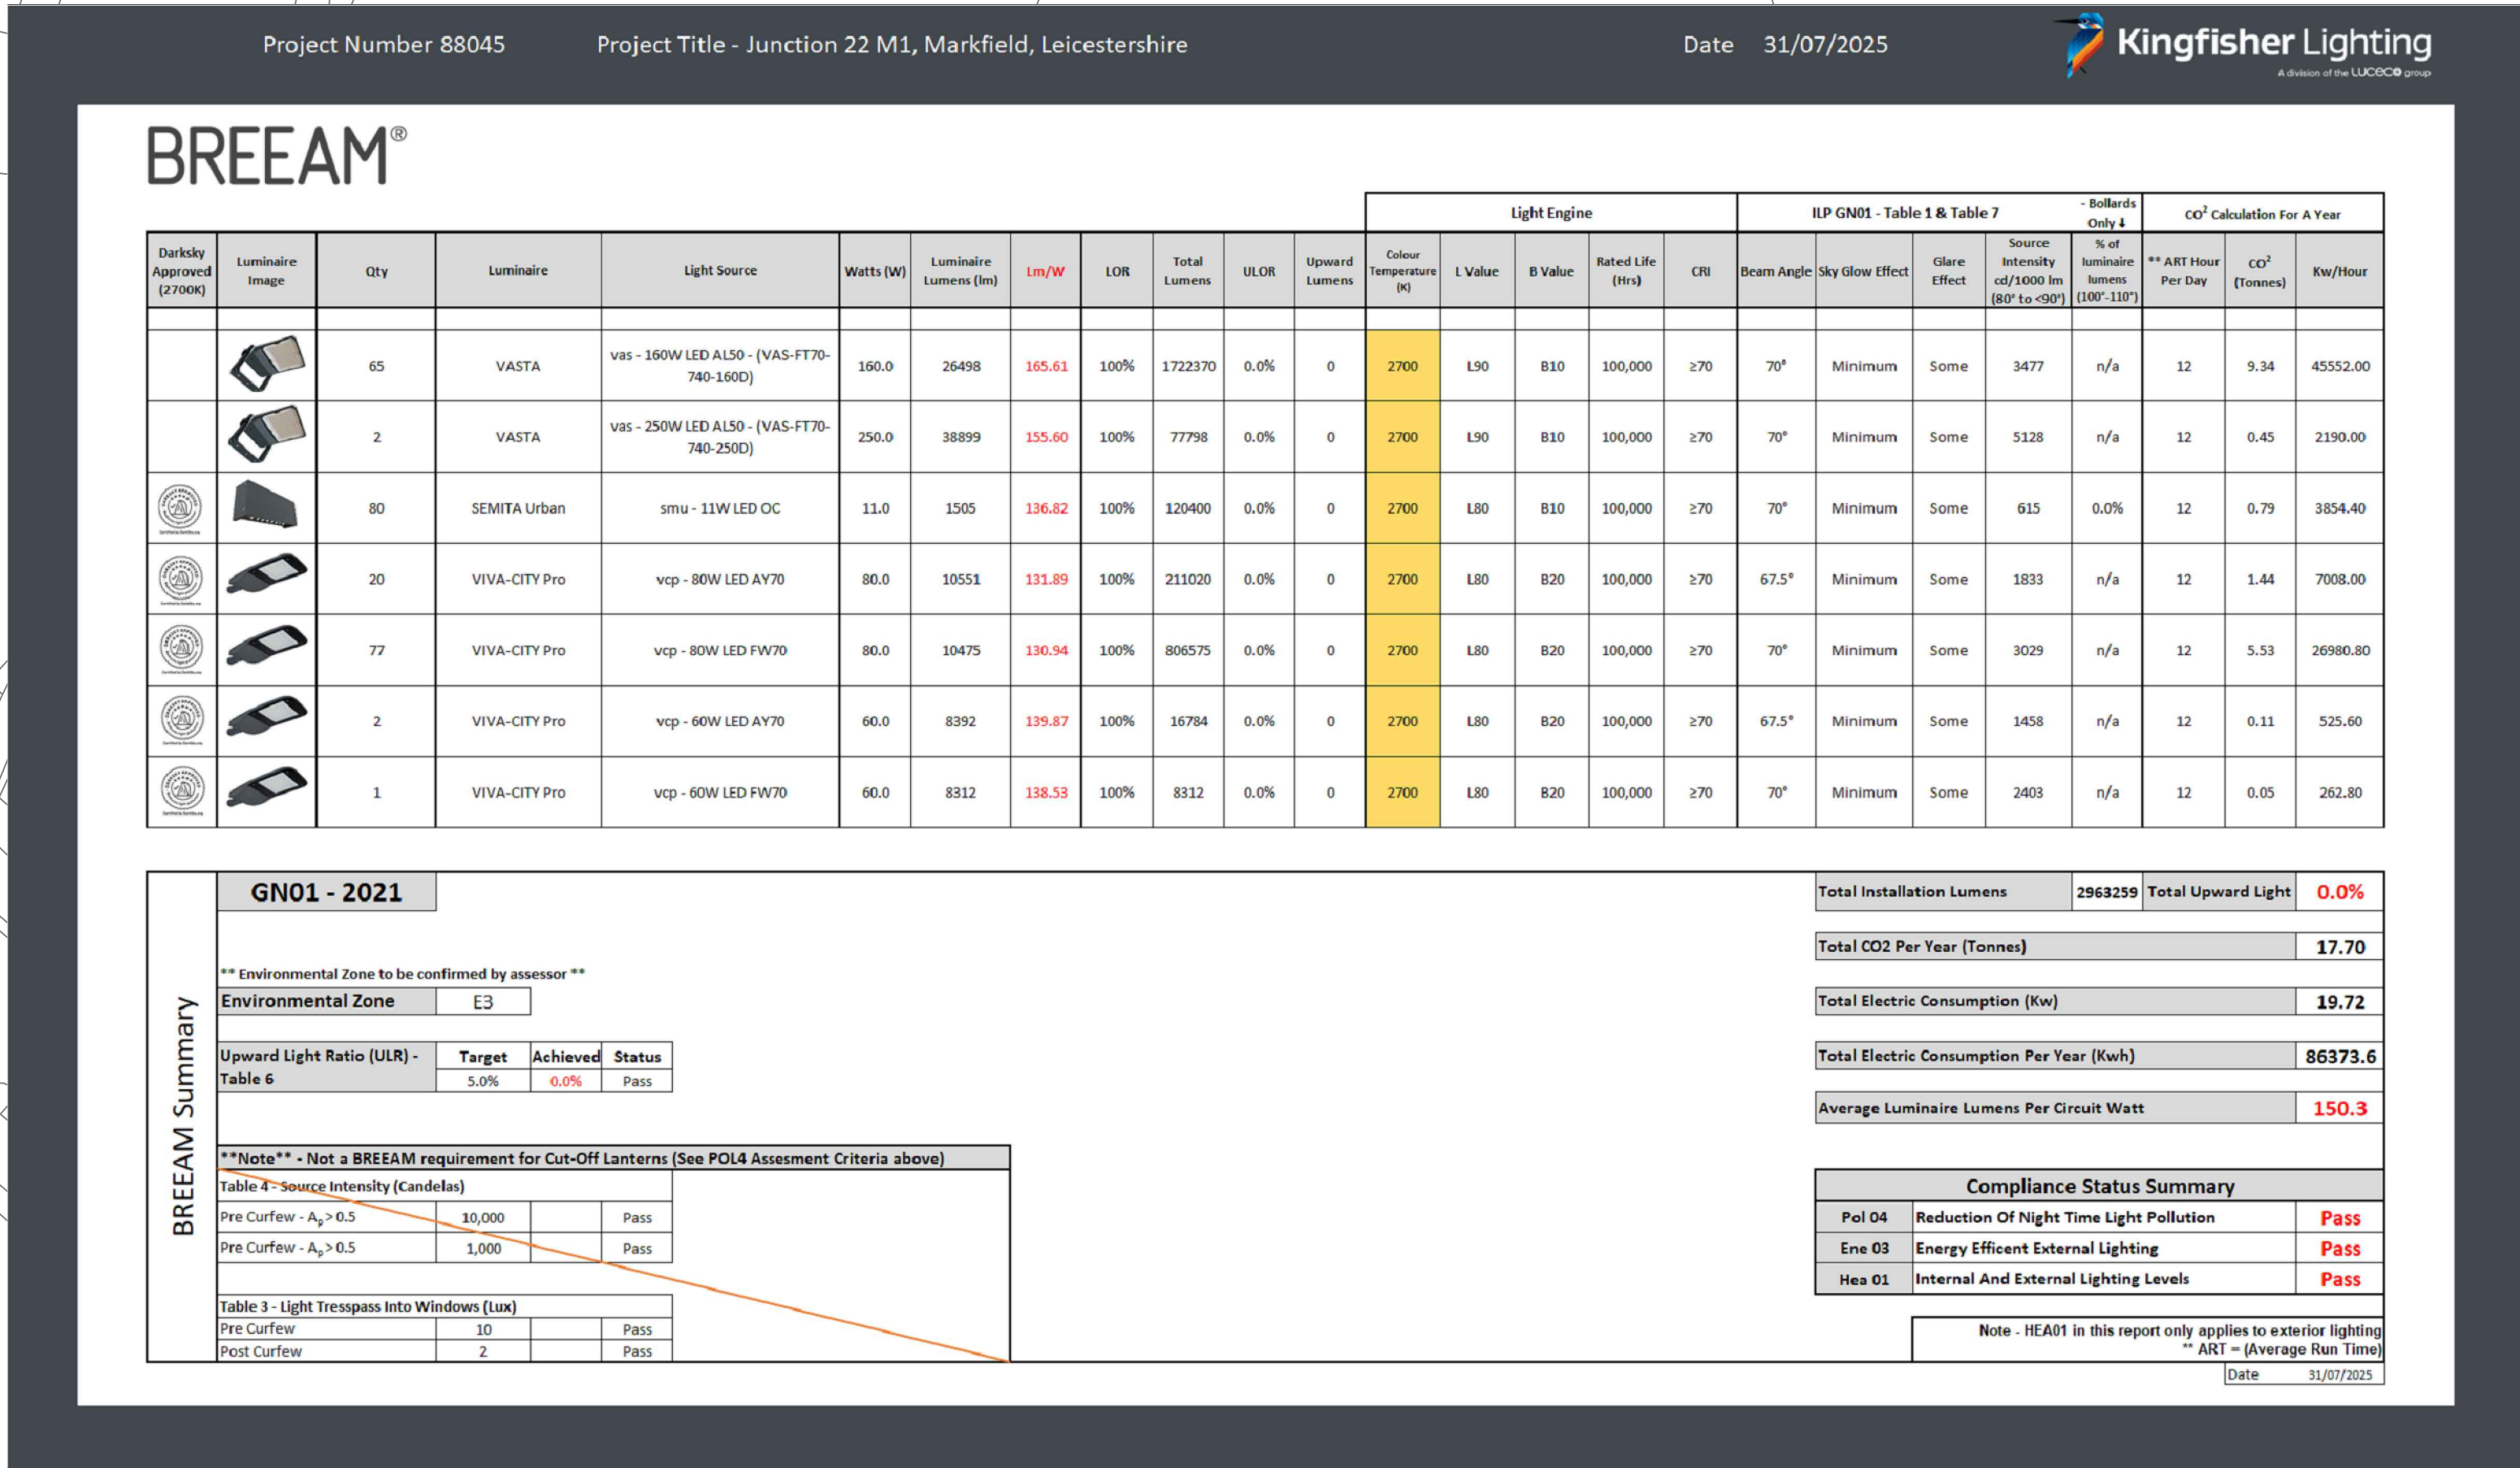

- | | | | | |
|-----|--|-------|---------|------------|
| P03 | UPDATED TO INCORPORATE CLIENT COMMENTS | BL | SGC | 23.08.2025 |
| P04 | MASTER SITE PLAN LAYOUT UPDATED | BL | SGC | 22.08.2025 |
| P02 | LIGHTING ALTERED TO INCLUDE CLIENTS COMMENTS | PMAR | BL | 12.08.2025 |
| P06 | PRELIMINARY ISSUE | PMAR | SGC | 18.01.2025 |
| Rev | Description | Drawn | Checked | Date |
- Status: **PRELIMINARY**
- 

ESP **Services Consultants**
Part of the Grubbs Group

Engineering Services Partnership Ltd
e-mail: esp@espbl.co.uk www.espbl.co.uk

☐ Croydon ☐ Edinburgh ☒ Manchester ☒ Peterborough

11 Swan Court, Cynnet Park, Hampton, Peterborough PE7 8GX
Tel: +44 (0)1733 312 373

Project CDL MARKFIELD			
Drawing Title ELECTRICAL SERVICES ROAD WAY LUX LEVELS			
Project No.	50091	Scale	NTS @ A0
Drawing No.	50091/E/111		Revision P04
Date JULY 2025	Designed MMor	Drawn MMor	Checked BL
All information contained upon this drawing remains the property of Engineering Services Partnership Limited and may not be copied part or whole without written permission.			