


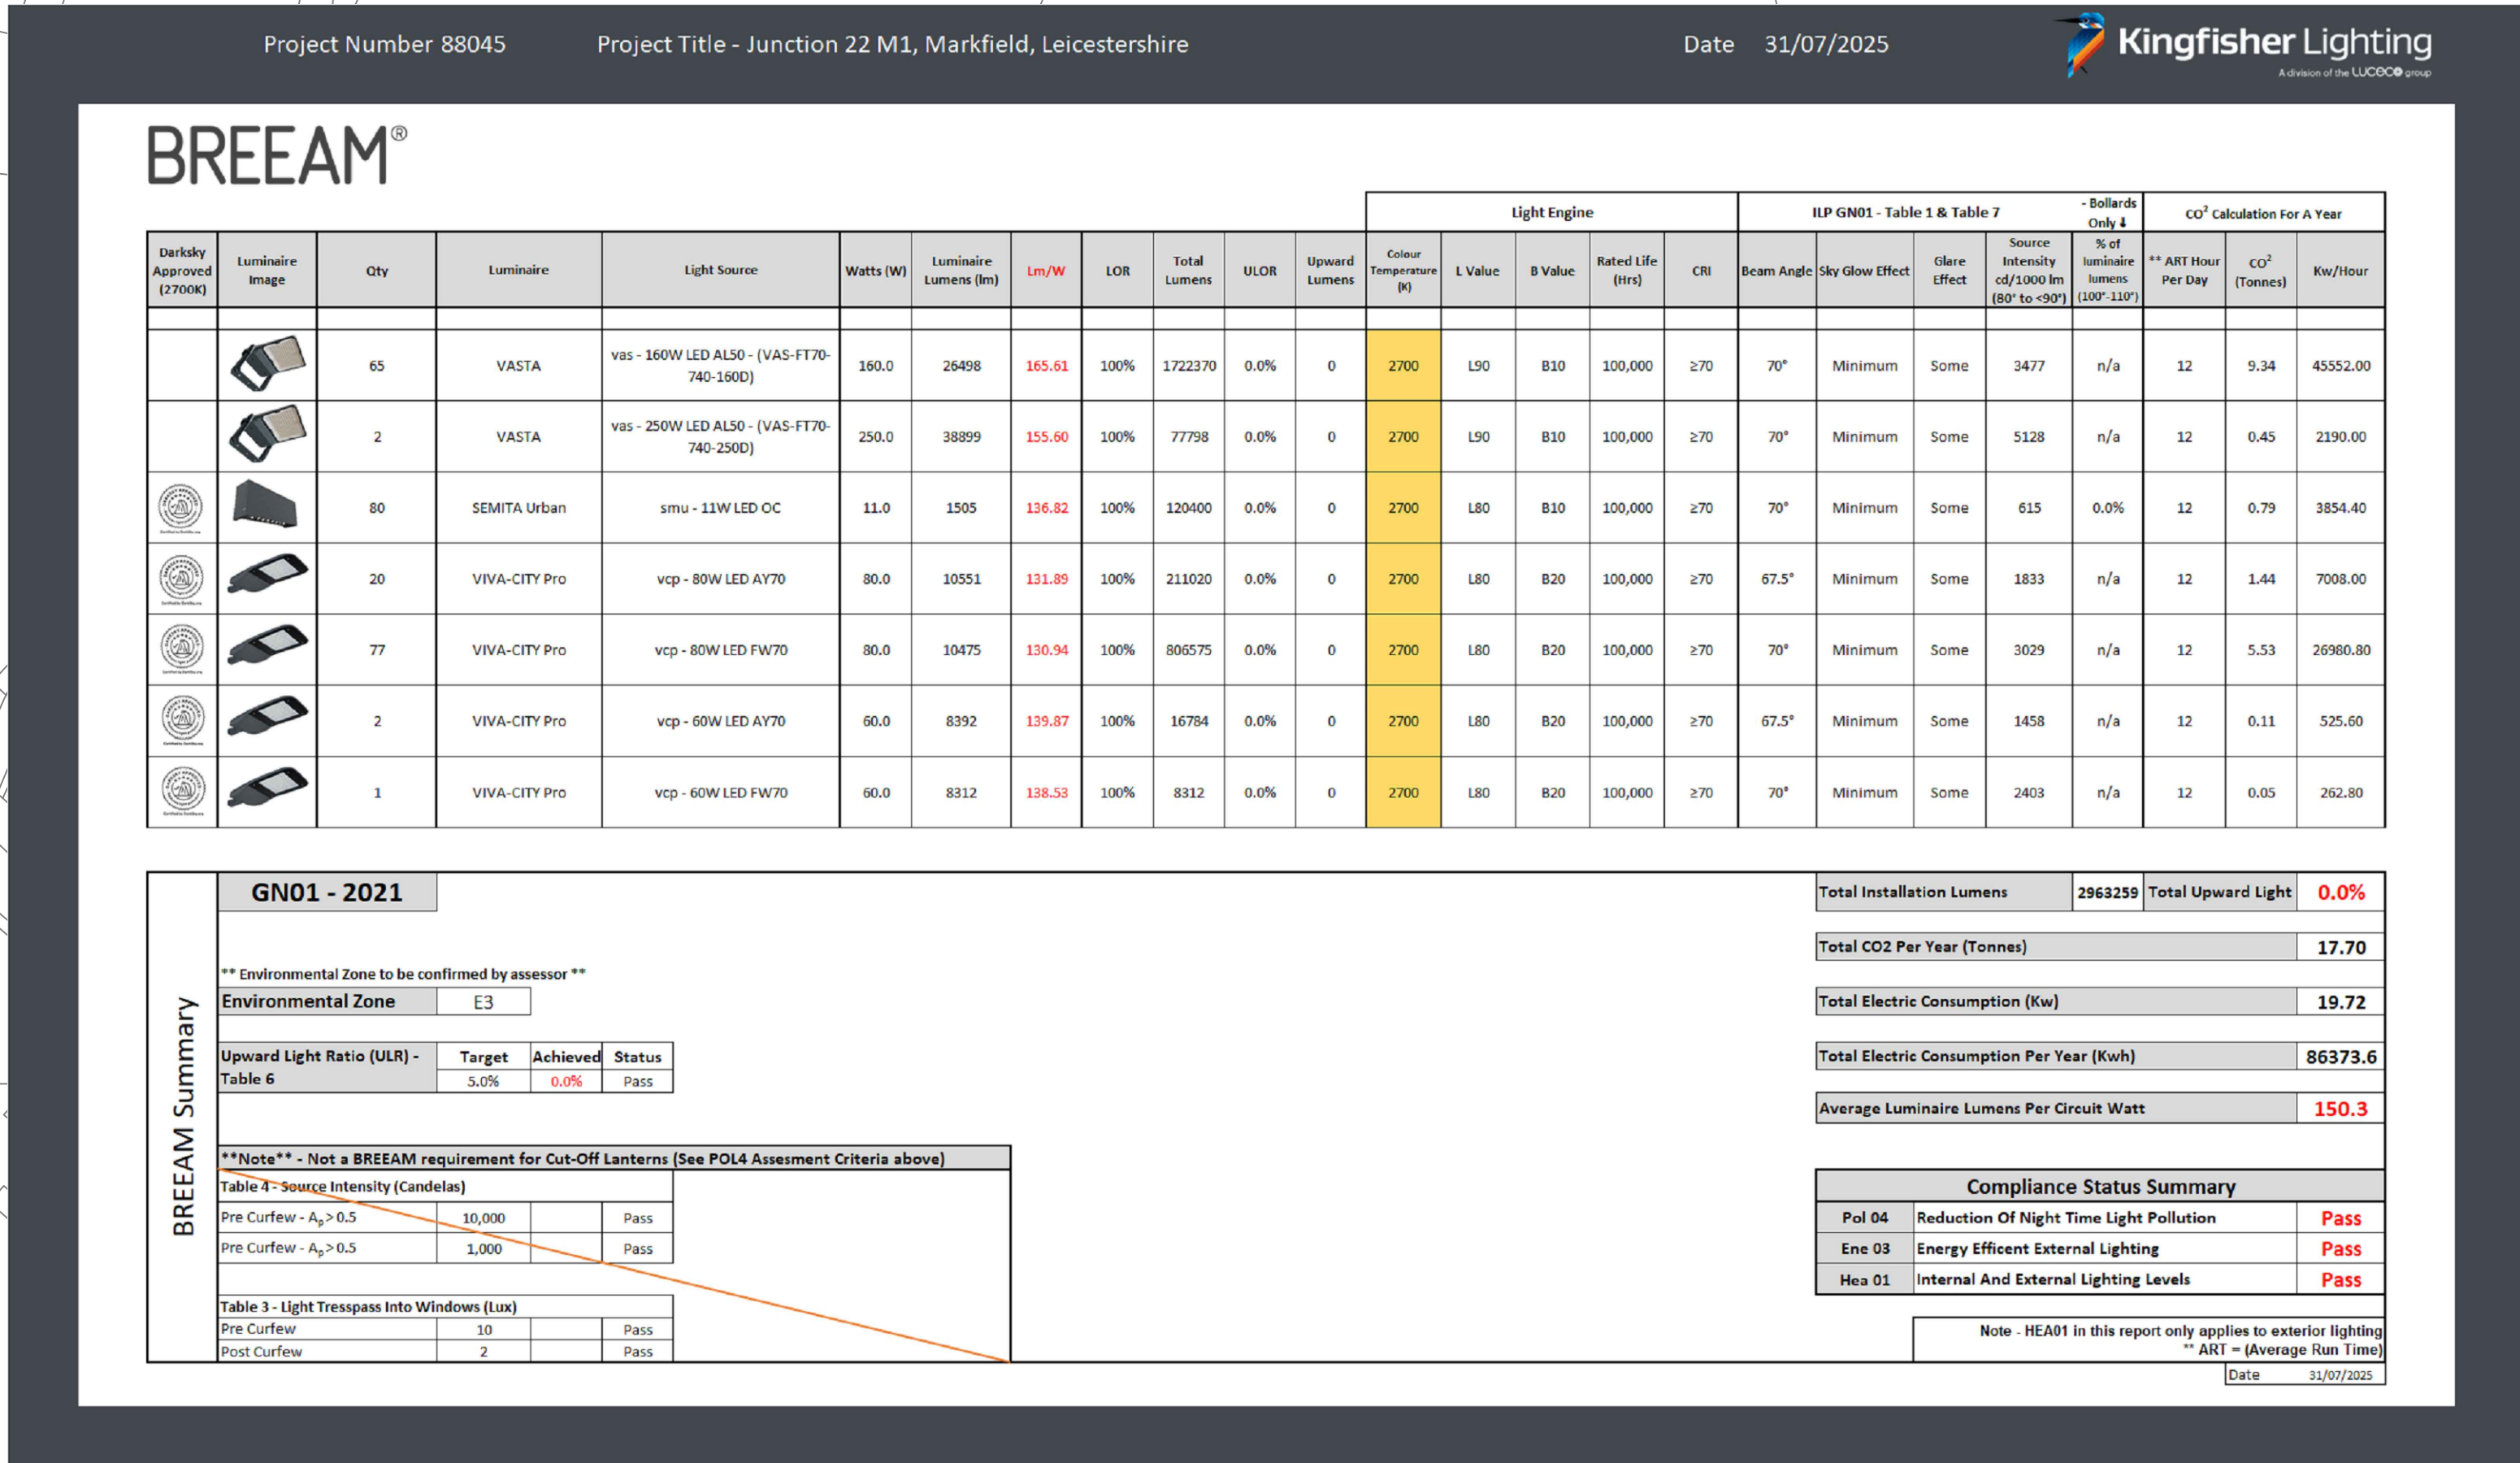

- | | | | | |
|------|---|-------|---------|------------|
| PO4 | UPDATED TO RECAPORATE CLIENT COMMENTS | BL | JCC | 22.08.2025 |
| PO3 | WASTEL SITE PLAN LAYOUT UPDATED | BL | JCC | 22.08.2025 |
| PO2 | LIGHTING ADDED TO ILLUSTRATE CLIENTS COMMENTS | PMH | BL | 22.08.2025 |
| PO1 | PRELIMINARY ISSUE | MDR | JCC | 22.07.2025 |
| Date | Descriptor | Drawn | Checked | Date |
- STATUS: **PRELIMINARY**
- 

ESp Services Consultants
Part of the Gensler Group

Engineering Services Partnership Ltd

e-mail: esp@esp.co.uk Web: www.esp.co.uk
- ☐ Craydon
 ☐ Edinburgh
 ☐ Manchester
 ☐ Peterborough
 11 Swan Court, Cynnet Park, Hampton, Peterborough PE7 8GX
 Tel: +44 (0)1753 312 373

CADDICK DEVELOPMENTS LTD				
Project CDL MARKFIELD				
Drawing Title ELECTRICAL SERVICES EXTERNAL LIGHTING LAYOUT				
Project No. 50091/E/112		Code		NTS @ A0
Drawing No.		Revision		004
Date July 2025	Designed MMar	Drawn MMar	Checked	JGC
All drawings submitted under this drawing remain the property of Caddick Developments Partnership Limited and may not be copied part or whole without a written permission.				