


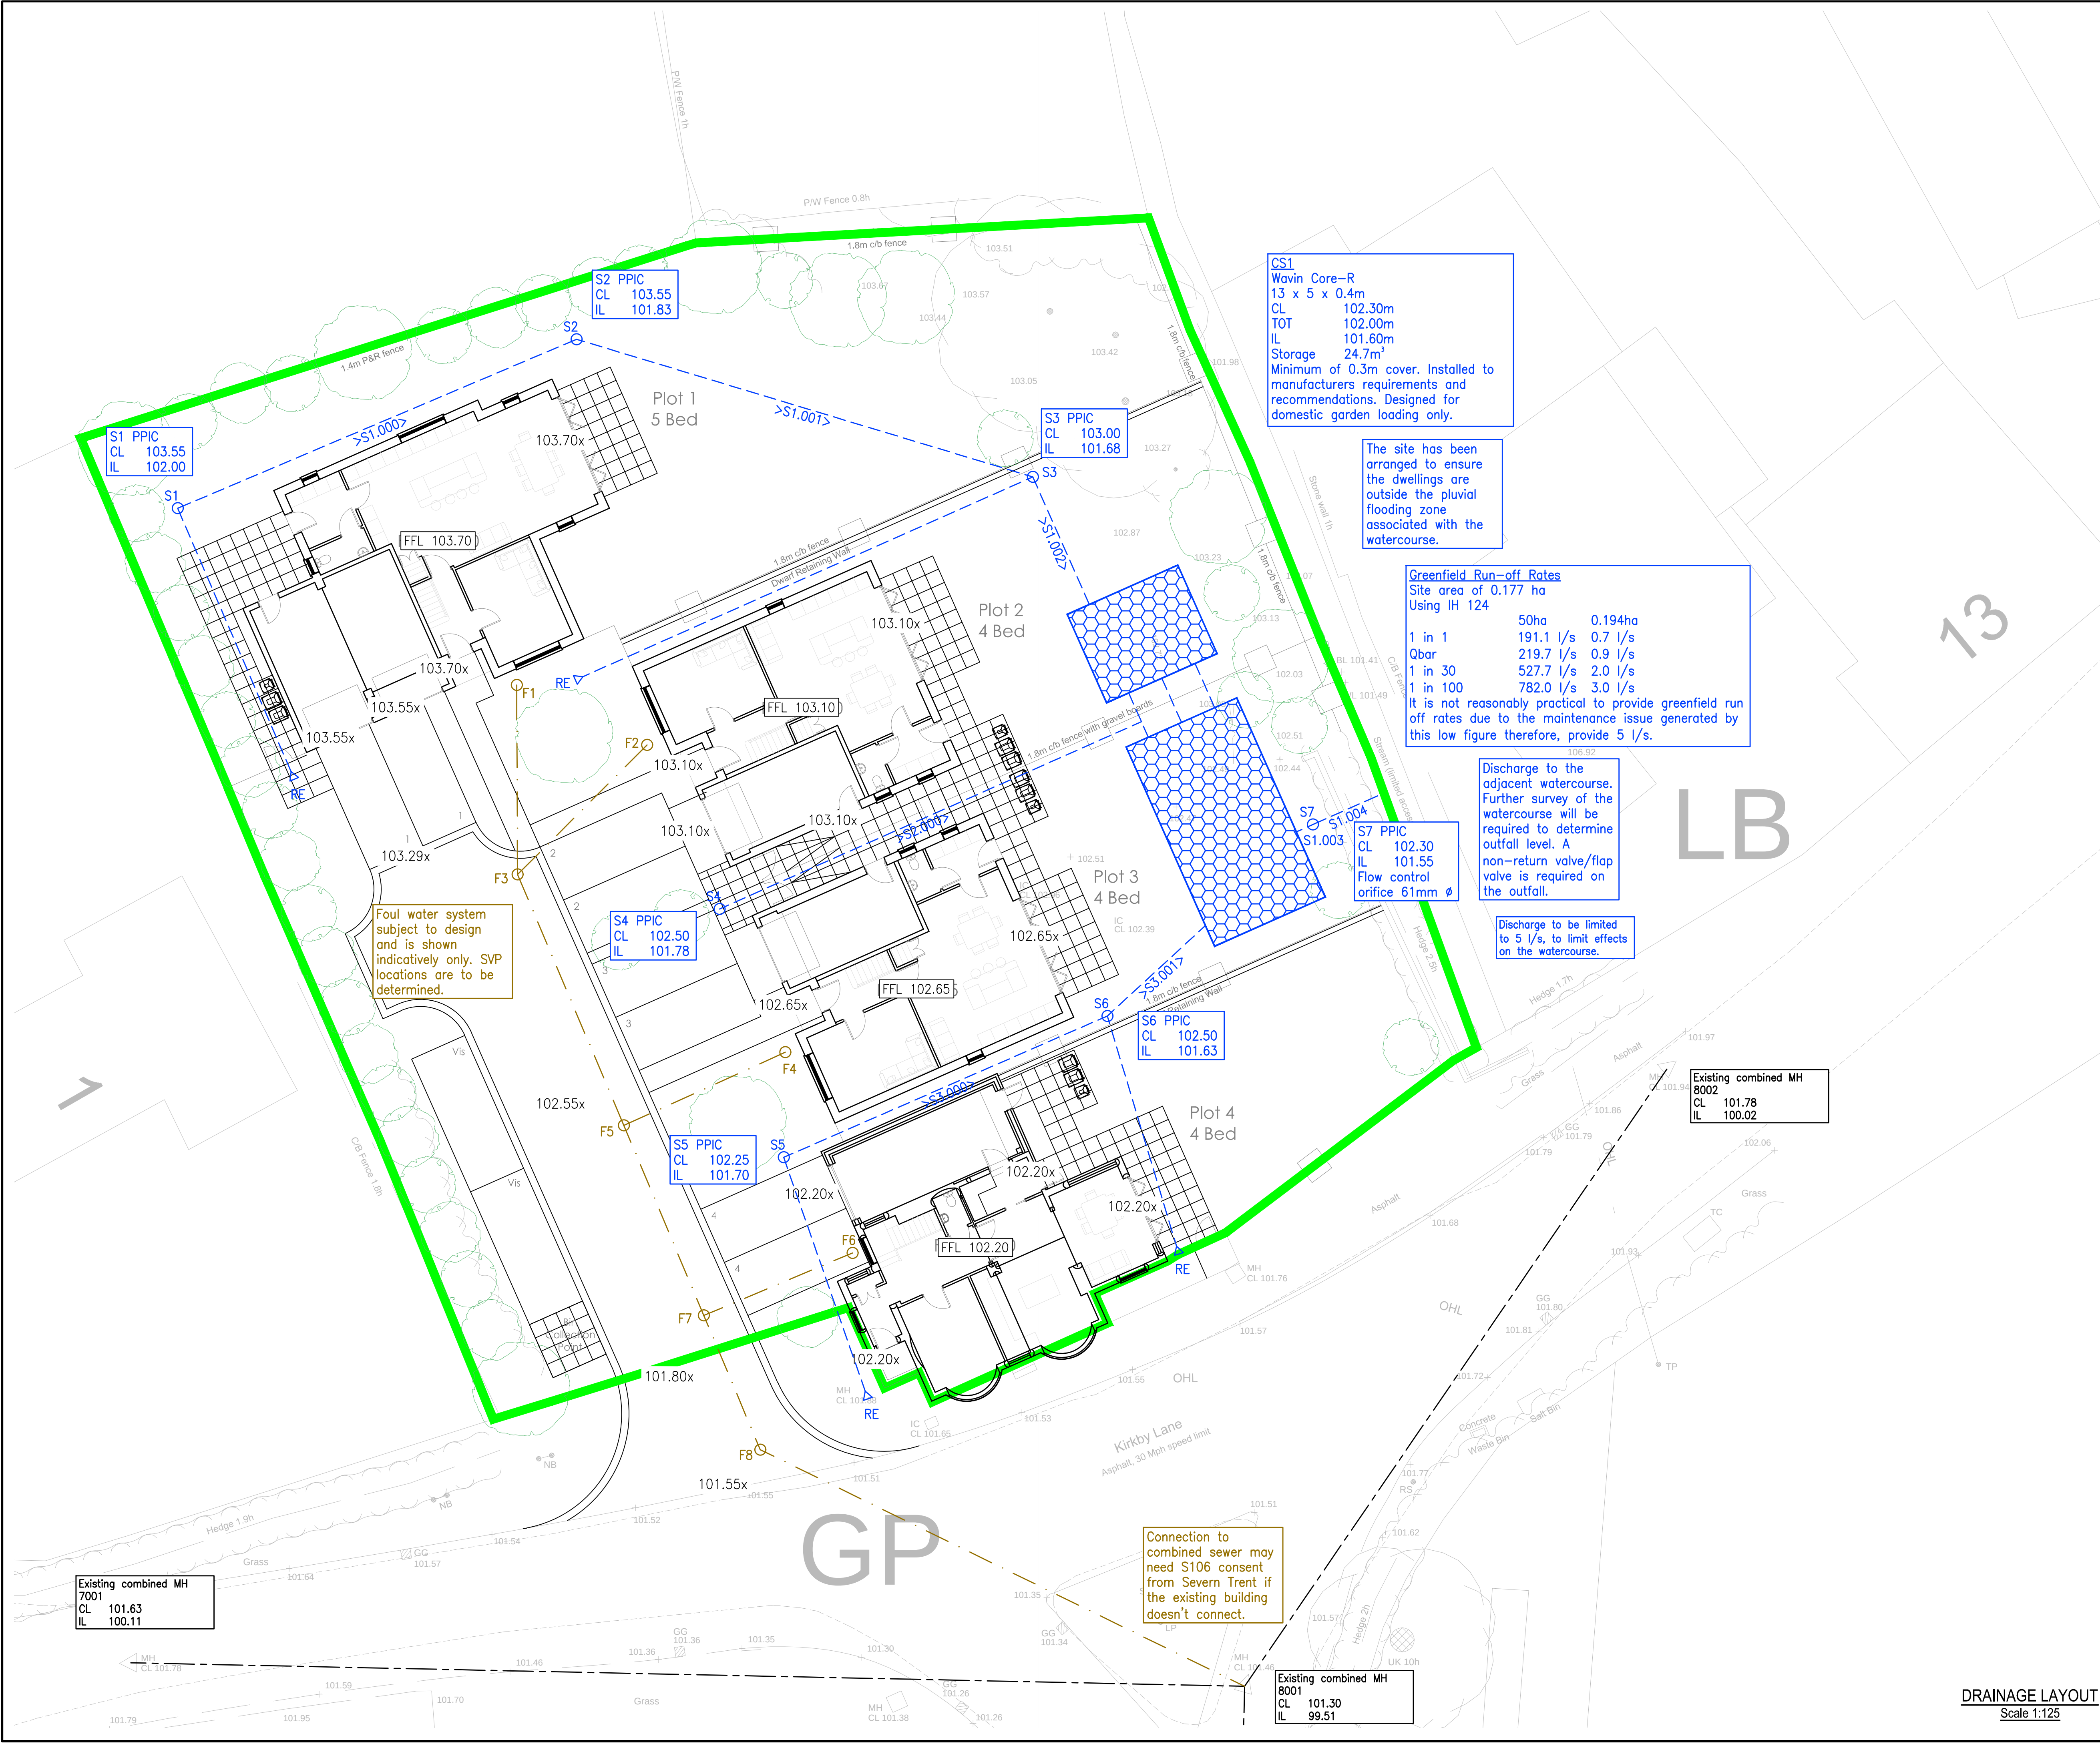

DO NOT SCALE

This drawing is the copyright protected intellectual property of Diamond Wood & Shaw Limited and is not to be used or reproduced in any way without our written permission.

- NOTES
- THIS DRAWING IS TO BE READ IN CONJUNCTION WITH ALL OTHER DWS DRAWINGS, CALCULATIONS, REPORTS AND SPECIFICATIONS (WHERE APPLICABLE) AND, ALL OTHER RELEVANT ENGINEERS, ARCHITECTS & SPECIALIST DESIGN DETAILS.
 - STANDARD NOTES & DETAILS:**
Refer to drawing number 0-170 onwards for standard notes - CIVIL
Refer to drawing number 0-180 onwards for standard details - CIVIL



All dimensions to be verified by accurate site measurement prior to commencing work or ordering materials.

- KEY
- Surface Water Pipe (Adoptable)
 - Surface Water Pipe (Private)
 - Surface Water Pipe (Perforated)
 - Surface Water Rising Main (Adoptable)
 - Surface Water Rising Main (Private)
 - Surface Water Pipe (Lateral)
 - Surface Water Chamber (Adoptable)
 - Surface Water Chamber (Private)
 - Rodding Eye
 - Gully
 - Linear Drain
 - Attenuation Tank
 - Soakaway
 - Permeable Paving
 - Fin Drain
 - Foul Water Pipe (Adoptable)
 - Foul Water Pipe (Private)
 - Foul Water Rising Main (Adoptable)
 - Foul Water Rising Main (Private)
 - Foul Water Pipe (Lateral)
 - Foul Water Chamber (Adoptable)
 - Foul Water Chamber (Private)
 - Back Inlet Gully/Foul Gully
 - Combined Water Pipe (Adoptable)
 - Combined Water Pipe (Private)
 - Combined Water Rising Main (Adoptable)
 - Combined Water Rising Main (Private)
 - Combined Water Chamber (Adoptable)
 - Combined Water Chamber (Private)
 - Exceedence Flow Route
 - Concrete Pipe Protection
 - Sewer Easement
 - Existing Surface Water Sewer
 - Existing Foul Water Sewer
 - Existing Combined Water Sewer
 - Root Protection Area
 - Site Boundary

P1	First issue	16.10.23	LM
Ref	Revision	Date	By

PRELIMINARY

DWS
Consulting Engineers

Diamond Wood & Shaw Limited
The Old School • Babay Road • Enderby • Leicester • LE19 4AR
Tel: 0115 284 8889 • Email: mail@dwsltd.co.uk

Project Title
**LITTLE INDIA RESTAURANT,
7 MAIN STREET
PECKLETON**

Drawn LM	Engineer LM	Checked RAS
Scale at 1:125 @ A1		Date OCT 2023

Drawing Title
DRAINAGE LAYOUT

Project No. 23-20082	Drawing No. 0-500	Revision P1
--------------------------------	-----------------------------	-----------------------

BIM Code

NOT FOR CONSTRUCTION

DRAINAGE LAYOUT
Scale 1:125