



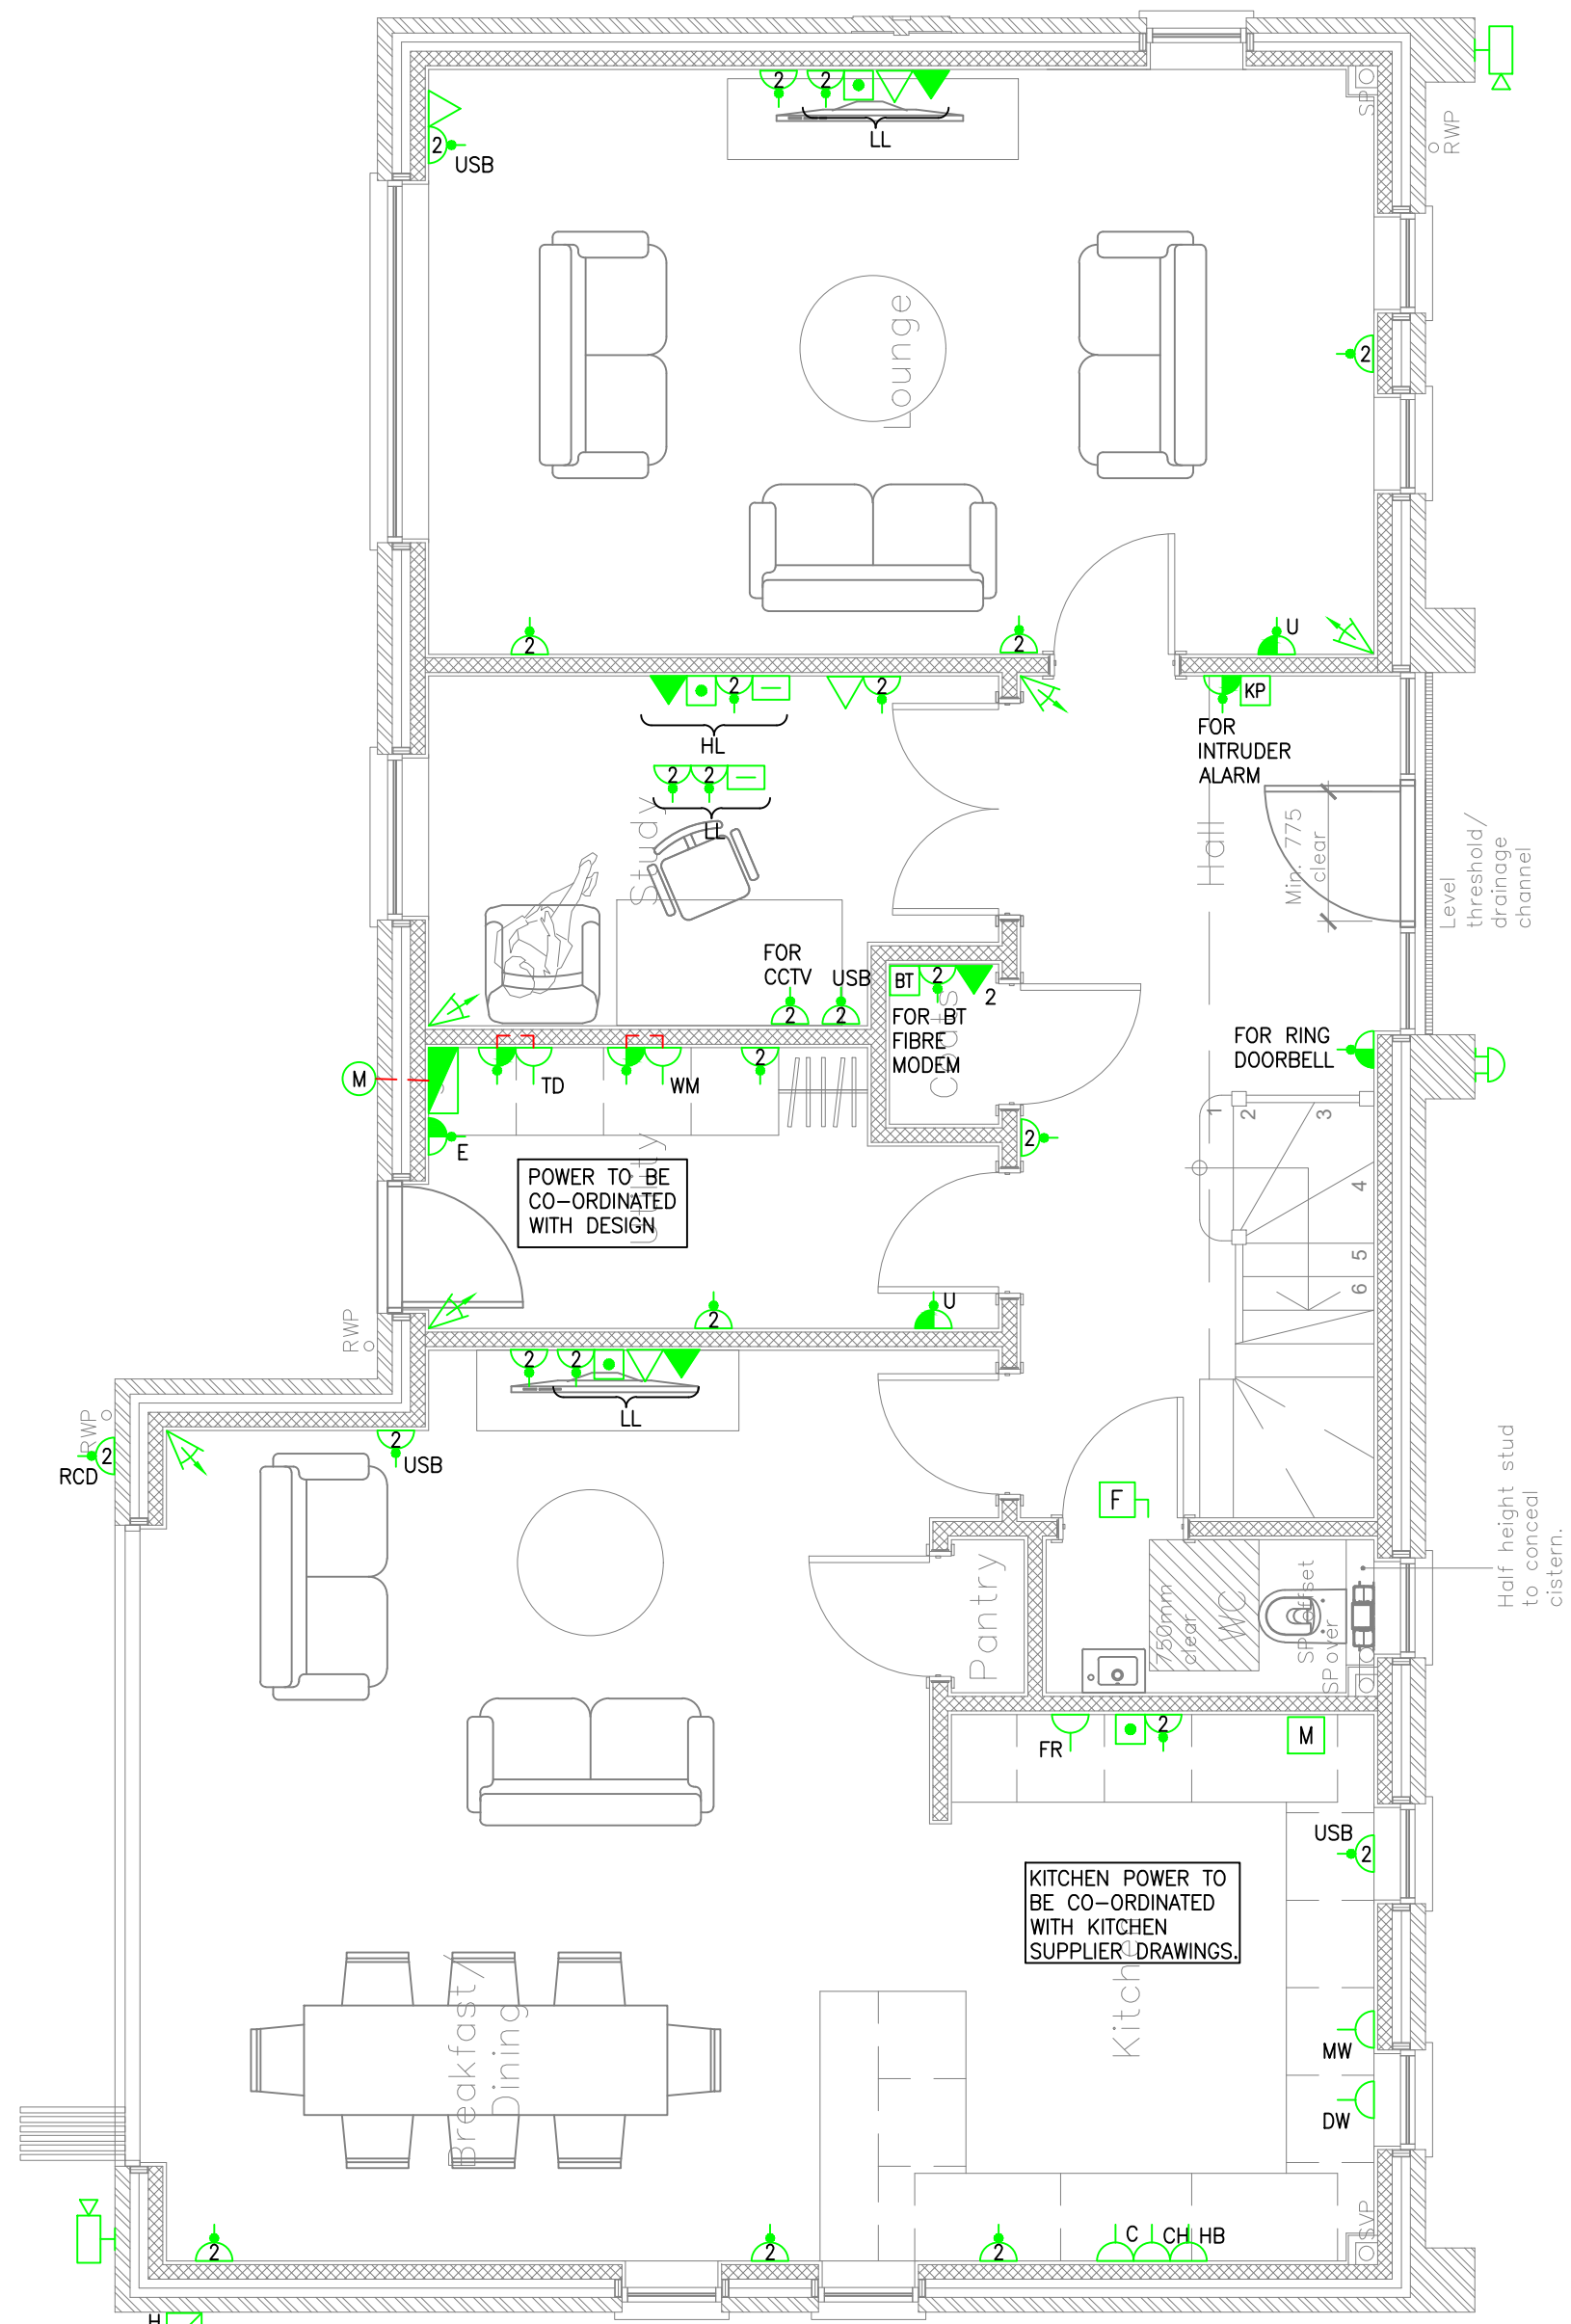


GROUND FLOOR


- SMALL POWER LEGEND**
- TWIN SWITCHED SOCKET OUTLET
 - POP UP TWIN SWITCHED SOCKET OUTLET
 - TWIN SWITCHED SOCKET OUTLET WITH INTEGRAL USB CHARGING POINT
 - SINGLE SWITCHED SOCKET OUTLET
 - EXTERNAL SOCKET OUTLET WITH RCD, AS MK MASTERSAL IP66
 - SINGLE UNSWITCHED SOCKET OUTLET
 - SWITCHED FUSED CONNECTION UNIT
 - FLEXIBLE OUTLET
 - DOUBLE LETTERBOX CABLE OUTLET
 - TELEPHONE OUTLET
 - TV POINT FOR FREEVIEW
 - MULTIGANG SWITCH PLATE FOR KITCHEN APPLIANCE ISOLATION SWITCHES
 - ACCESSORIES WITH 'X' ARE LABELLED TO INDICATE EQUIPMENT SERVED WHERE 'X' INDICATES:-
 - CH- COOKER HOOD HIGH LEVEL
 - HB- ELECTRIC HOOD
 - DW- DISHWASHER
 - FF- FRIDGE/FREEZER
 - M- BUILT IN MICROWAVE
 - V- WHOLE HOUSE VENTILATION UNIT
 - WD- WASHING MACHINE/DRYER
 - C- COOKER SWITCH
 - WM- MICROWAVE
 - V- UPH MANFOLD LOCATION
 - DM- MIRROR DE-MISTER
 - E- EXTRACT FAN UNIT
 - M- IMMERSON ELEMENT
 - N- HOT WATER CYLINDER
 - SH- DUAL VOLTAGE SHOWER OUTLET
 - TD- TUMBLE DRYER
 - TR- DUAL FUEL TOWEL RAIL WITH CABLE OUTLET LOCATED ADJACENT.
 - DEWATER TYPE MIRROR WITH LED LIGHTING AND INTEGRAL SHOWER SOCKET
 - CONSUMER UNIT/DISTRIBUTION BOARD
 - FAN ISOLATION SWITCH FOR FAN WITH RUN ON TIMER
 - RING DOOR BELL
 - SINGLE PHASE ROTARY ISOLATOR FOR AIR SOURCE HEAT PUMP OUTDOOR UNIT (LOCATION, RATING & SIZE TBC)
 - SEM RECESSED ELECTRIC METER CUPBOARD
 - CCTV CAMERA
 - SINGLE DATA POINT
 - INTRUDER ALARM PIR (INDICATIVE LOCATIONS TO BE CONFIRMED BY SPECIALIST)
 - INTRUDER ALARM KEYPAD
 - INTRUDER ALARM EXTERNAL SOUNDER
 - BT OPEN REACH FIBRE MODEM/POWER SUPPLY UNIT

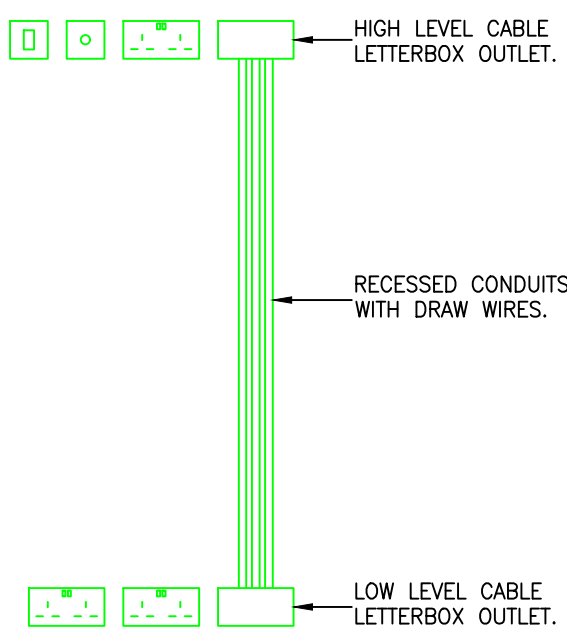


TYPICAL DETAIL FOR HIGH LEVEL TV LOCATIONS.

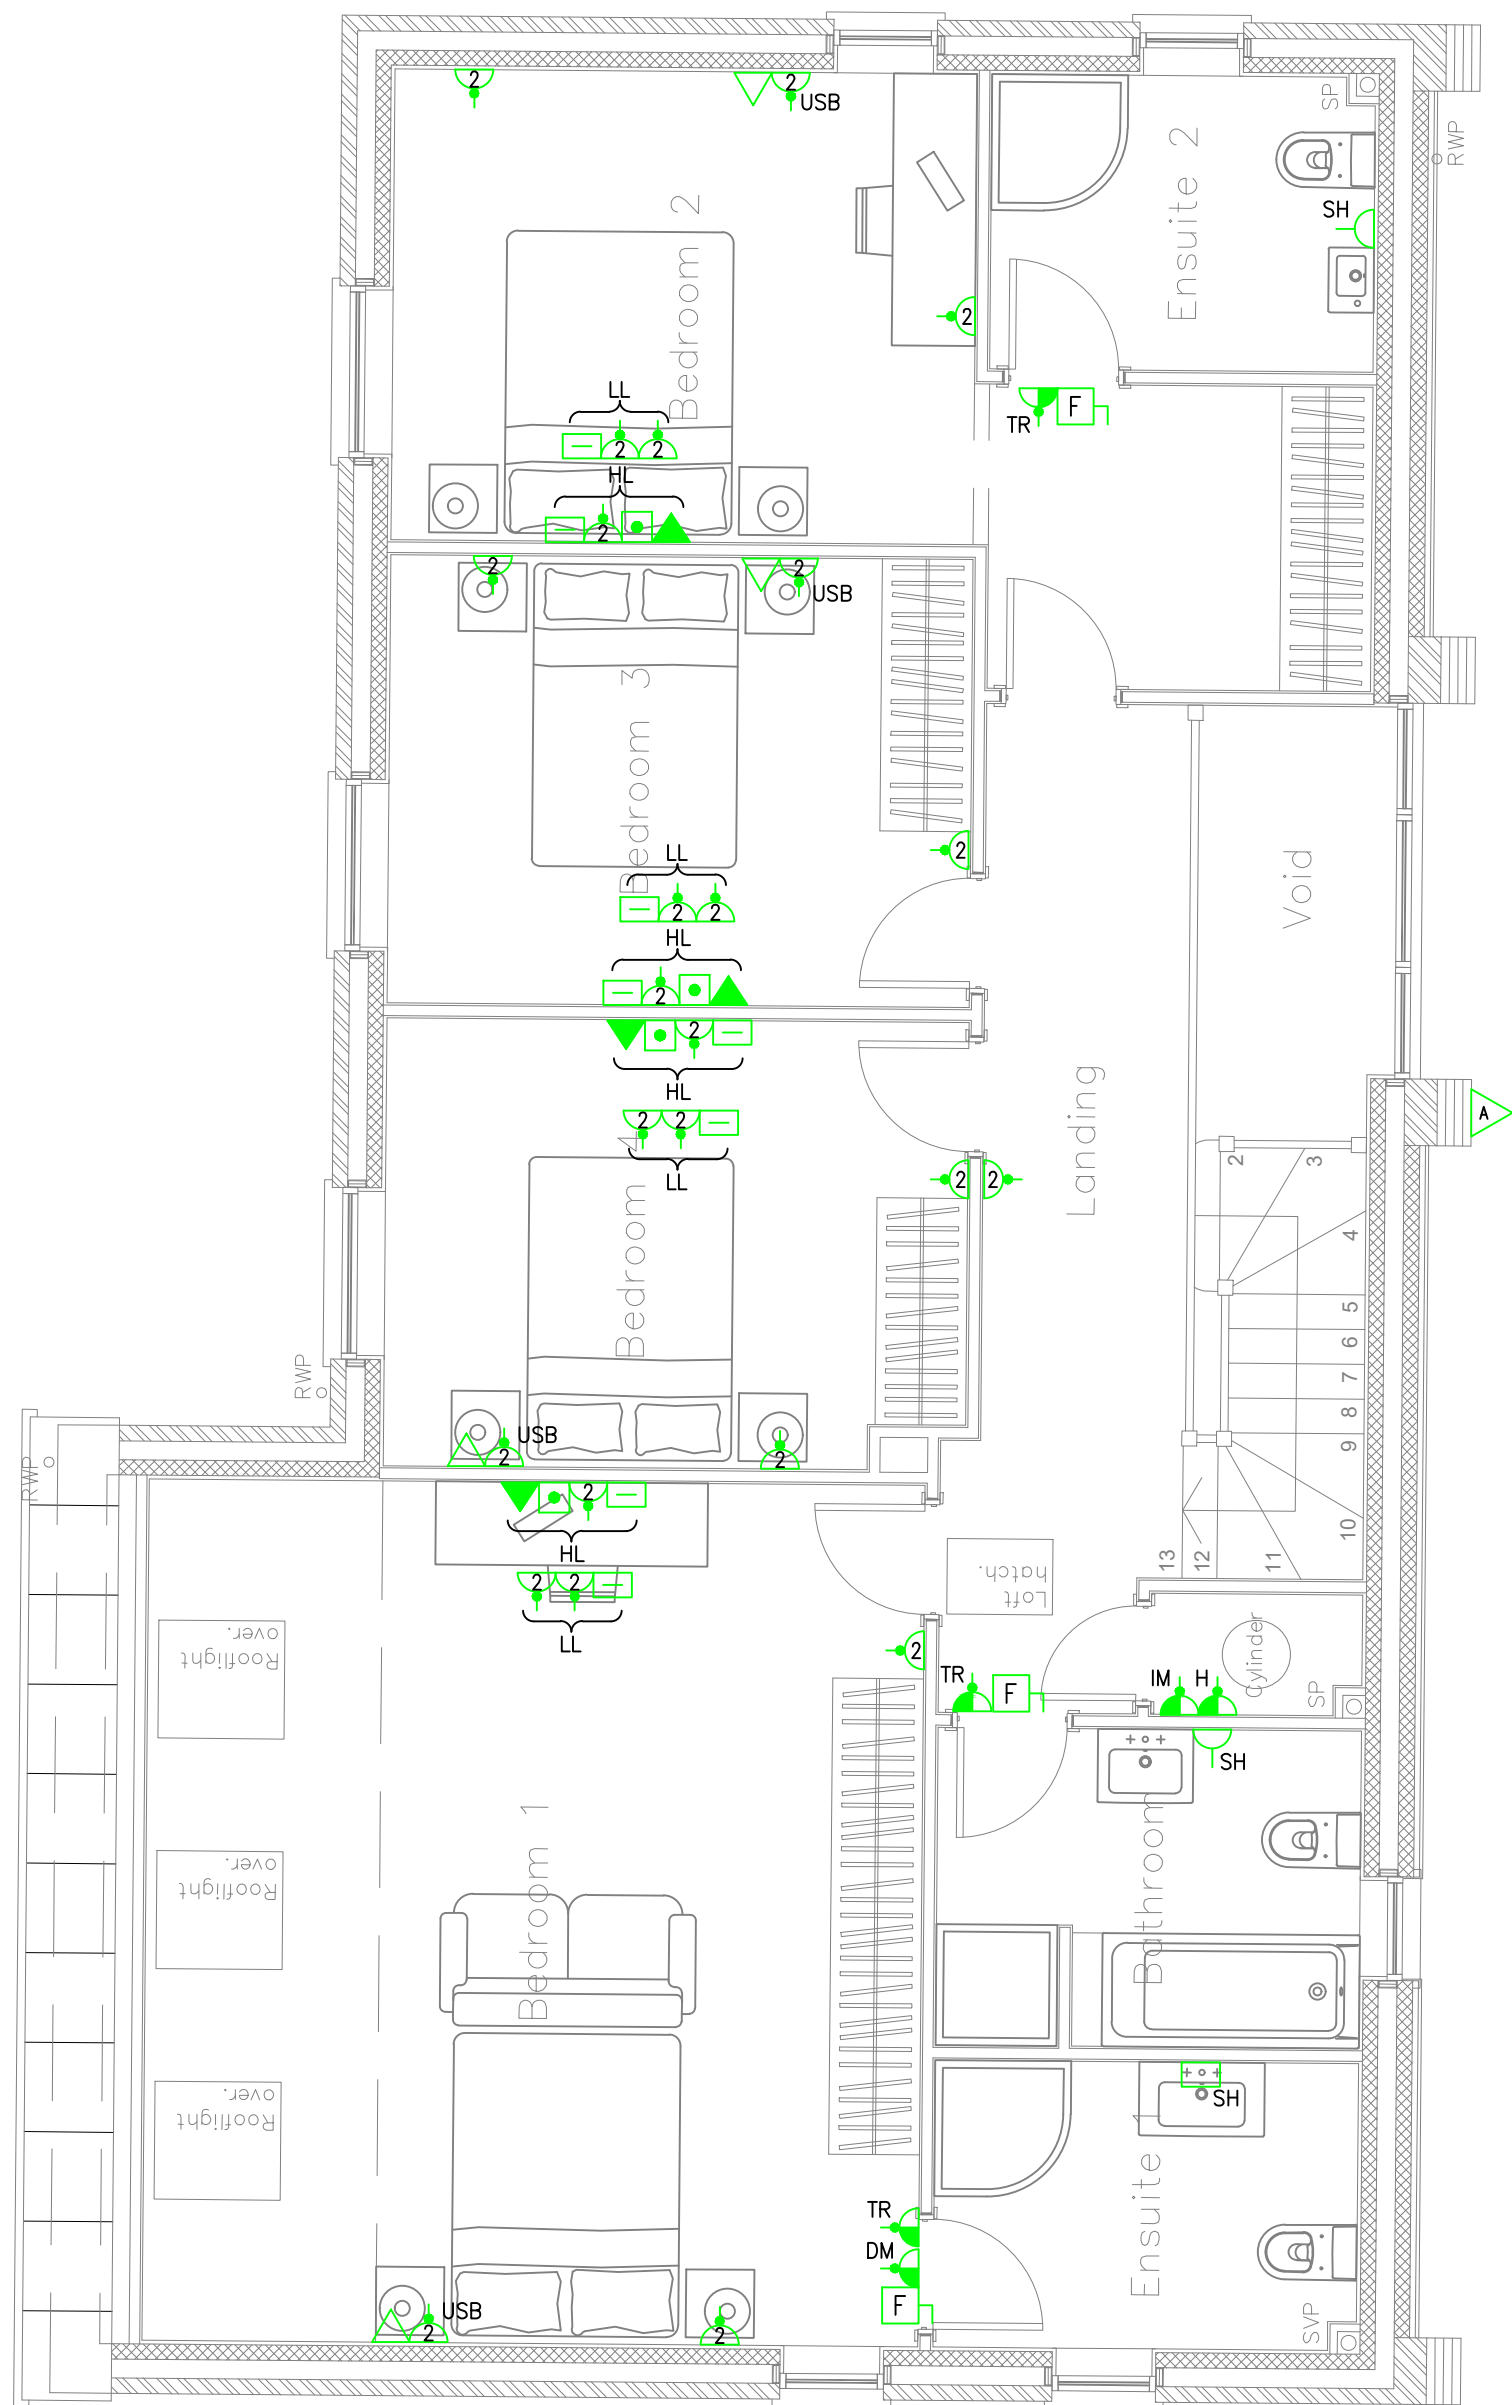

FIRST FLOOR
SMALL POWER

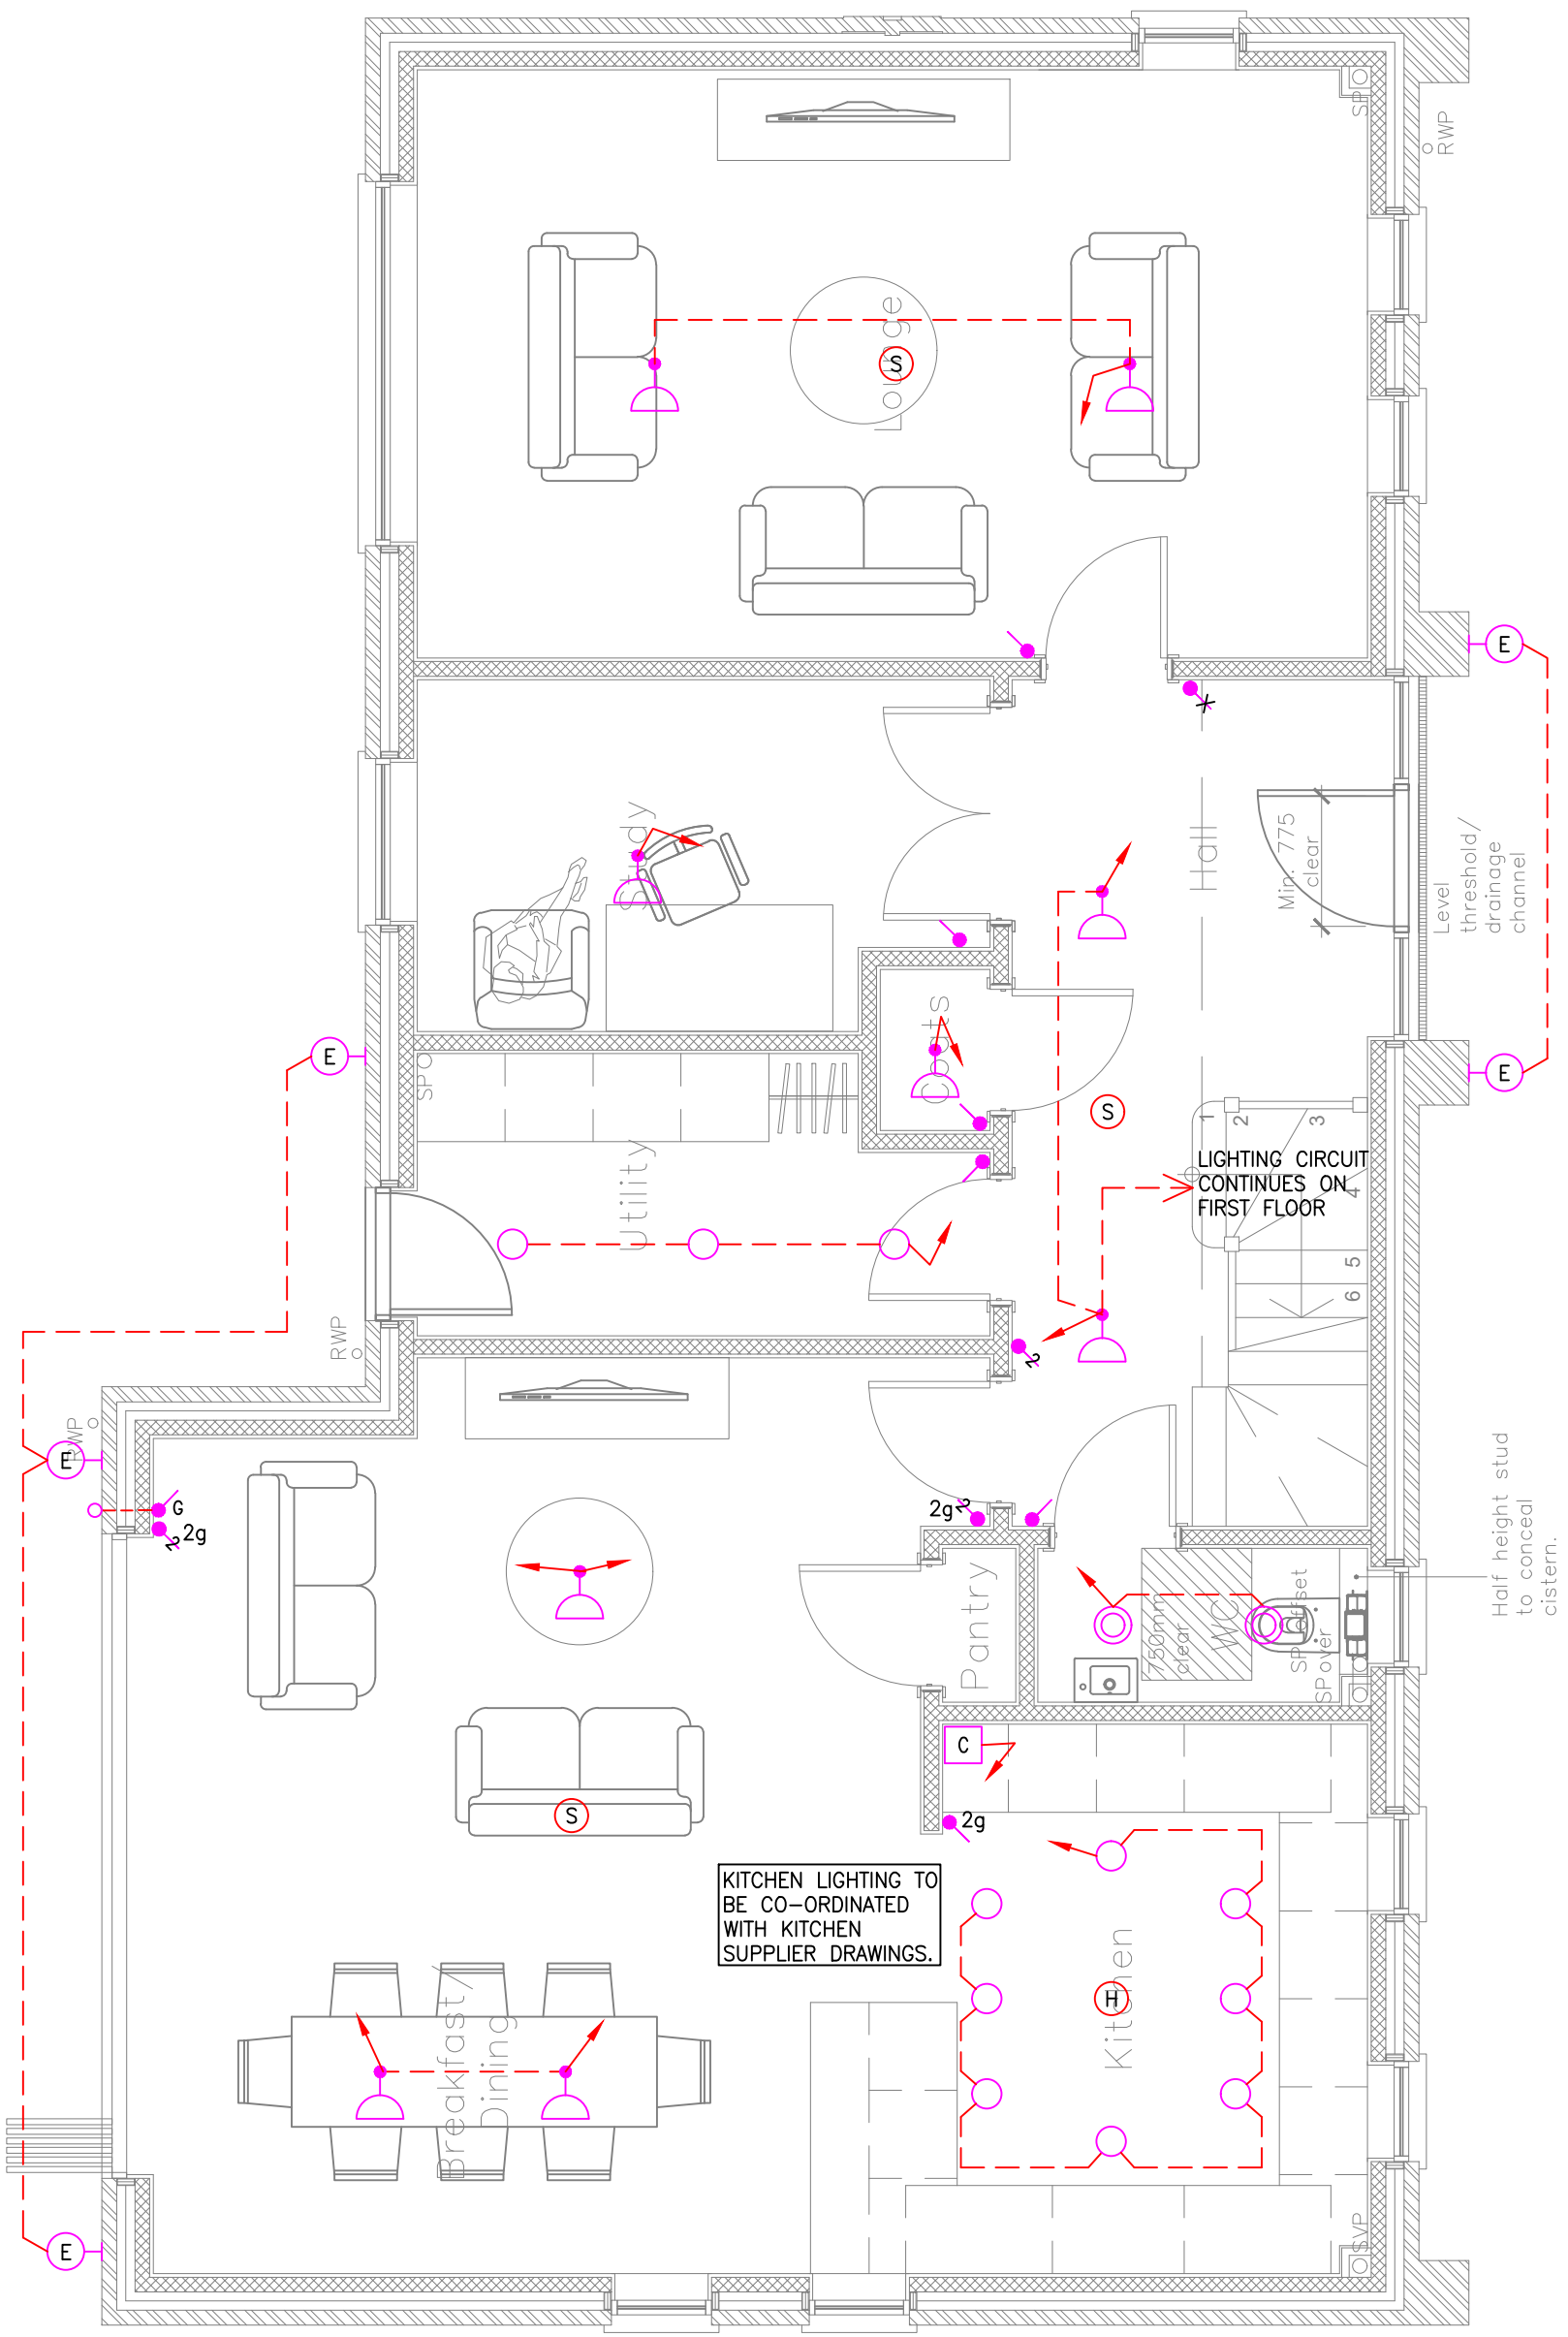

GROUND FLOOR

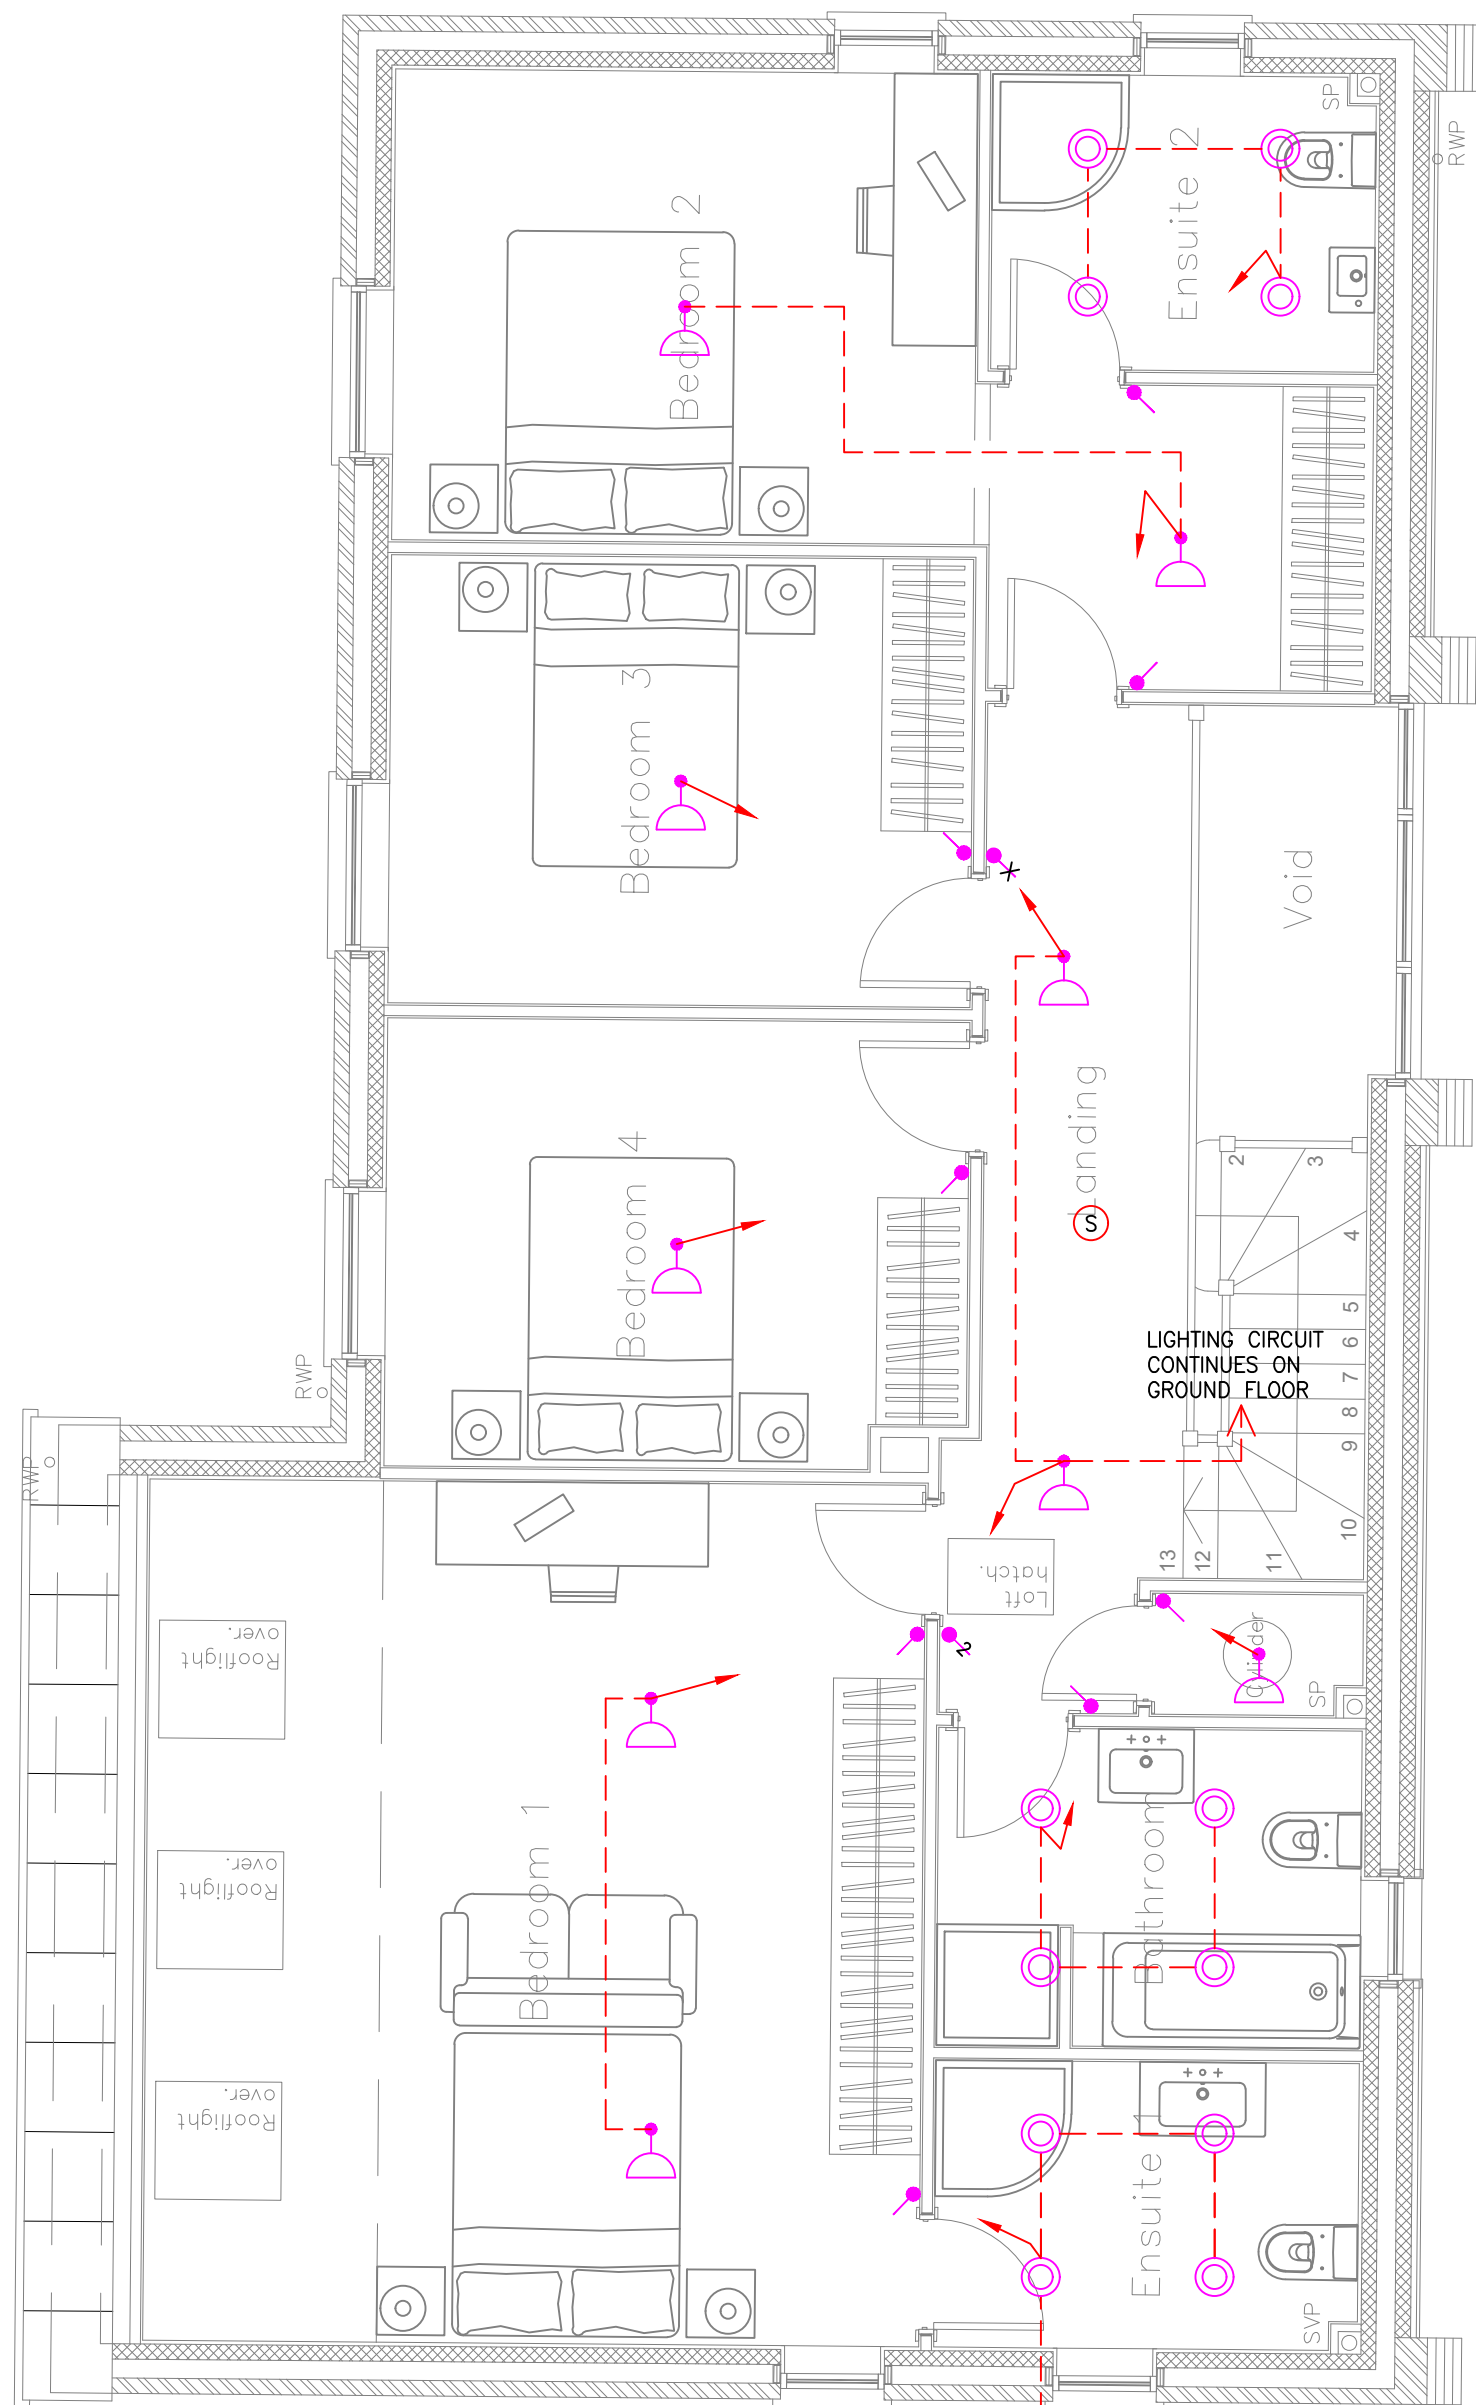

FIRST FLOOR
LIGHTING

- NOTES**
- DO NOT SCALE THIS DRAWING.
 - THIS DRAWING IS FOR TENDER PURPOSES ONLY. THE CONTRACTOR SHALL PROVIDE HIS OWN FULLY DETAILED AND CO-ORDINATED DESIGN AND INSTALLATION DRAWINGS.
 - THIS DRAWING IS TO BE READ IN CONJUNCTION WITH THE ENGINEERING SPECIFICATION.
 - THE CONTRACTOR SHALL REFER TO THE ARCHITECTURAL, STRUCTURAL ENGINEERING AND SPECIALIST DRAWINGS.
 - ALL SIZES, POSITIONS, QUANTITIES ETC OF PLANT AND EQUIPMENT IS INDICATIVE ONLY AND SUBJECT TO FINAL DESIGN BY THE CONTRACTOR AND APPROVAL BY THE ENGINEER.

LIGHTING LEGEND

- JCC RECESSED TWIST & LOCK FIT WITH WHITE FINISH & 4000K 7W LUMENFULNESS GU10 LED LAMP
- JCC RECESSED SHOWER SPOT IP65 WITH WHITE FINISH & 4000K 7W LUMENFULNESS GU10 LED LAMP
- IP44 SURFACE MOUNTED LINEAR FITTING
- LOW ENERGY LED CEILING PENDANT
- 1 WAY SWITCH 'x' DENOTES NUMBER OF GANGS
- INTERMEDIATE SWITCH 'x' DENOTES NUMBER OF GANGS
- 2 WAY SWITCH 'x' DENOTES NUMBER OF GANGS
- NOTE :
 - MULTIGANG SWITCHES TO BE WIRED SUCH THAT THE FIRST GANG (LEFT) SWITCHES THE FURTHEST CIRCUIT AND TO WORK ACROSS SO THE LAST SWITCH IS THE NEAREST CIRCUIT.
- LIGHT SWITCH FOR FUTURE GARDEN LIGHTS, WIRED TO LOW LEVEL SURFACE GALVANISED CONDUIT BESA BOX
- CONNECTION FOR CABINET LIGHTING
- SURFACE PIR
- EXTERNAL WALL MOUNTED FITTING AS SAKBY PALIN PIR 1LT WALL IP44 7W GU10 LED BRUSHED STAINLESS STEEL WITH CLEAR GLASS & INTEGRAL PIR

FIRE ALARM LEGEND

- DOMESTIC MAINS POWERED SMOKE DETECTOR/SOUNDER/BEACON
- DOMESTIC MAINS POWERED HEAT DETECTOR/SOUNDER/BEACON
- DOMESTIC MAINS POWERED CARBON MONOXIDE DETECTOR/SOUNDER/BEACON

P1	PRELIMINARY ISSUE	NK	03/05/22
REV	DESCRIPTION	BY	DATE

THE ENGINEERING PRACTICE

Chartered Mechanical and Electrical Consultants

GUNNERY HOUSE
GUNNERY TERRACE
LEAMINGTON SPA
CV32 3PE
TEL 01926 436010
FAX 01926 436020
www.theengineeringpractice.co.uk

CLIENT:
WHEATCROFT HOMES

PROJECT:
BARONS PARK FARM
KIRBY MUXLOE

DRAWING TITLE:
PLOT 2
SMALL POWER & LIGHTING LAYOUT

DRAWING NO.:
252/EI02

SCALE: 1:50 @A0
REVISION: P1

xref based on architects drawing

ENG/CAD:	NK/MGB	03/05/22
CHECKED:	NK	03/05/22