

 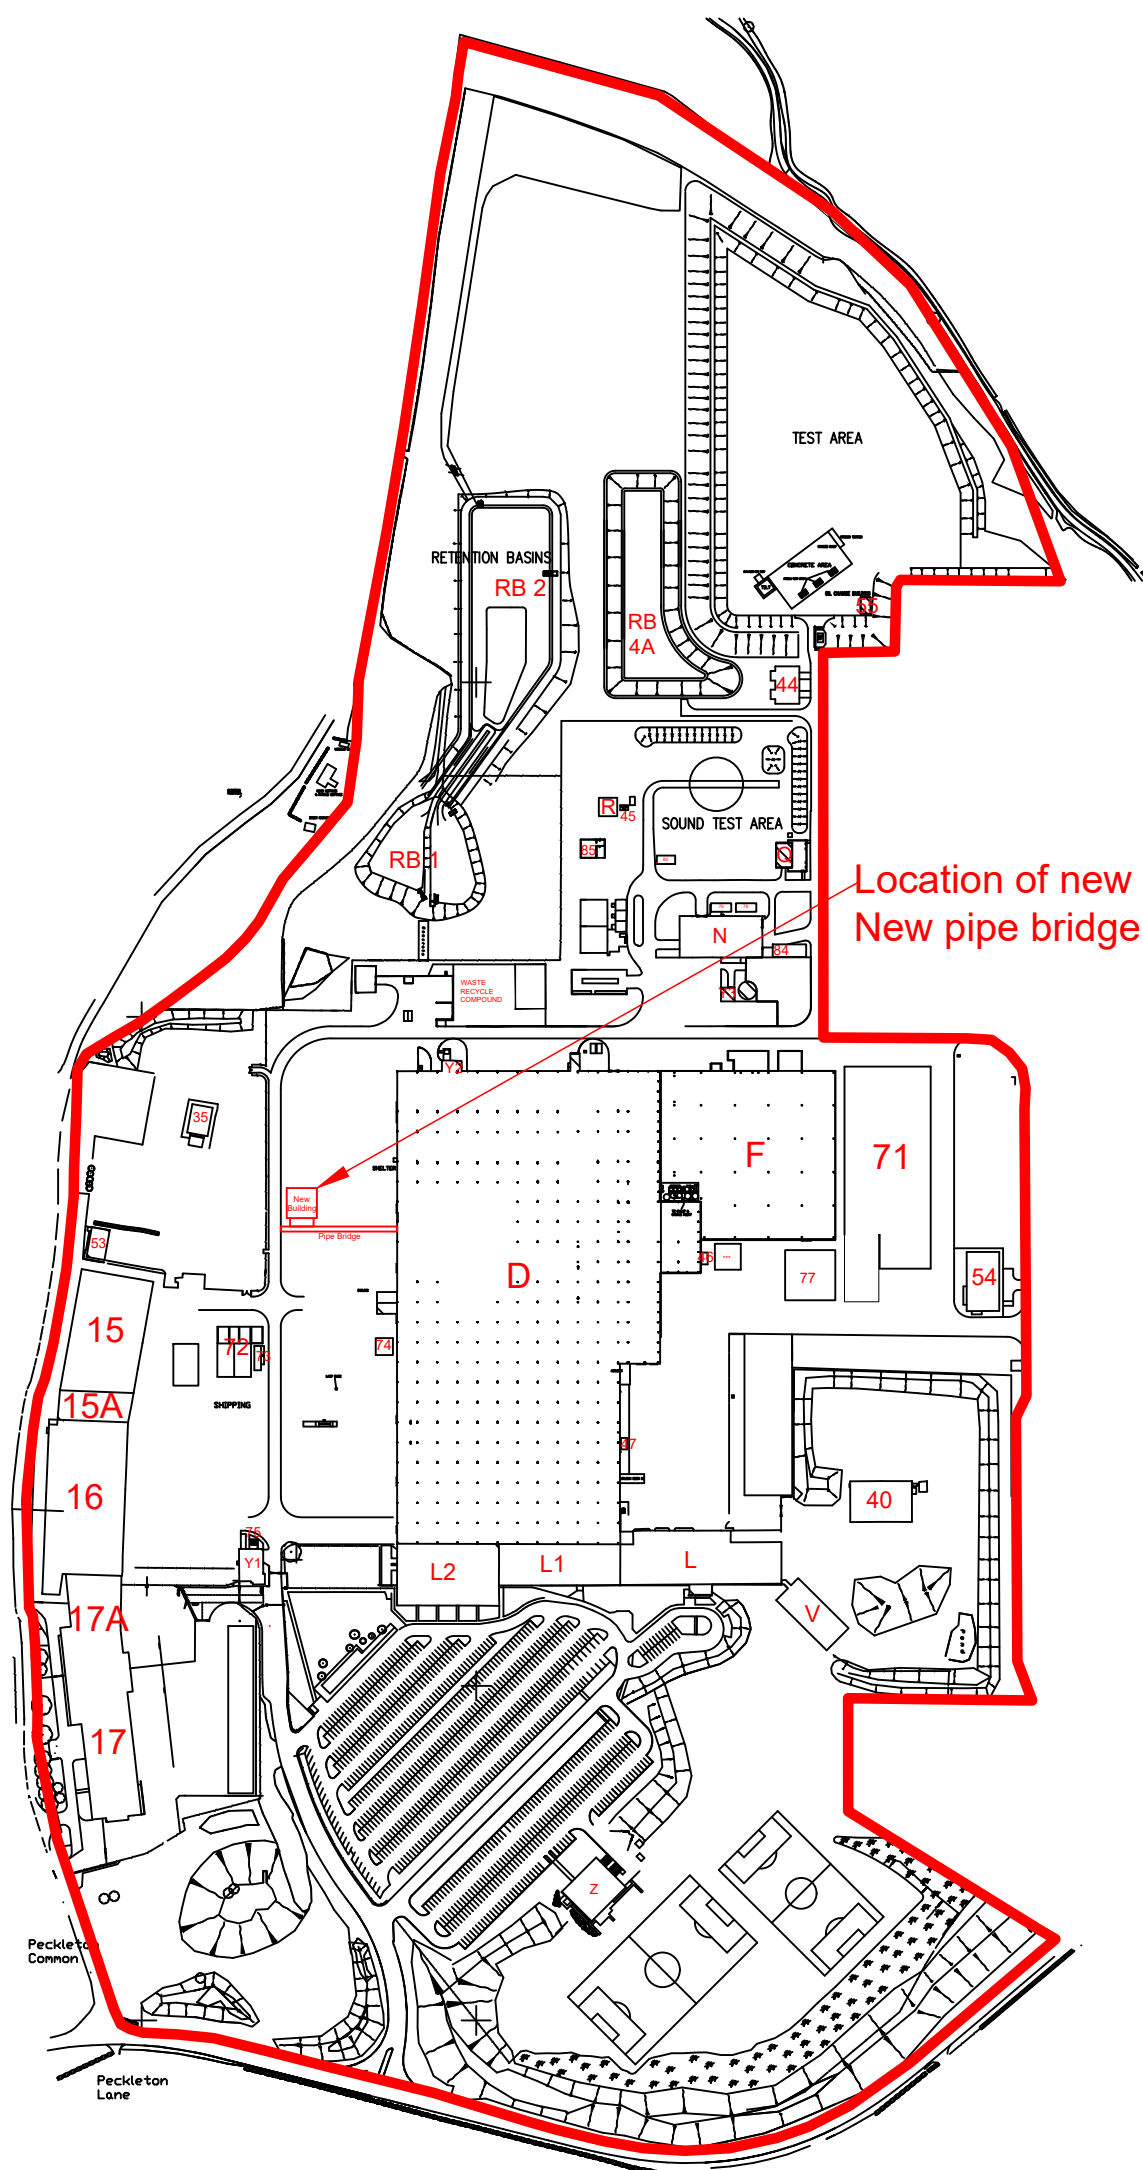


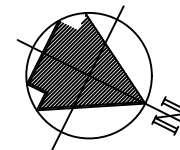

Location of new HVAC Processing Building: 394m²
New pipe bridge: 210m² @ 8 meters height

Caterpillar Uk Ltd
Peckleton Lane,
Desford,
Leicestershire
LE9 9JT



CATERPILLAR UK LTD SITE

R E V I S I O N S	DATE	Init	DETAILS
TITLE: Proposed Building Site Plan			
DWG No:			SCALE: 1:5000 on A3
DRAWN BY: S Lowe			DATE: 07/03/2025
C.A.D. FILENAME:			