

KEY TO SYMBOLS

- DRAINAGE RUN
- IC INSPECTION CHAMBER
- = RE RODDING EYE
- SC SAMPLE CHAMBER
- ▨ WATER TREATMENT PLANT
- ⊞ SOAKAWAY

Date	Description	Rev	By
------	-------------	-----	----

Revision Description





Project:
Proposed Glamping Site - For Chris McManus
Cold Comfort Farm, Rogues Lane, Hinckley,
Leicestershire, LE10 3DX

Drawing Title:
PROPOSED DRAINAGE PLAN

Drawing Number:
231154-01-04

Revision: -
Date: 07.12.2023
Scale: 1:200 @ A1
Drawn By: TA
CAD Dwg File: -
Checked By: -

Issue Status:
Full Planning Application

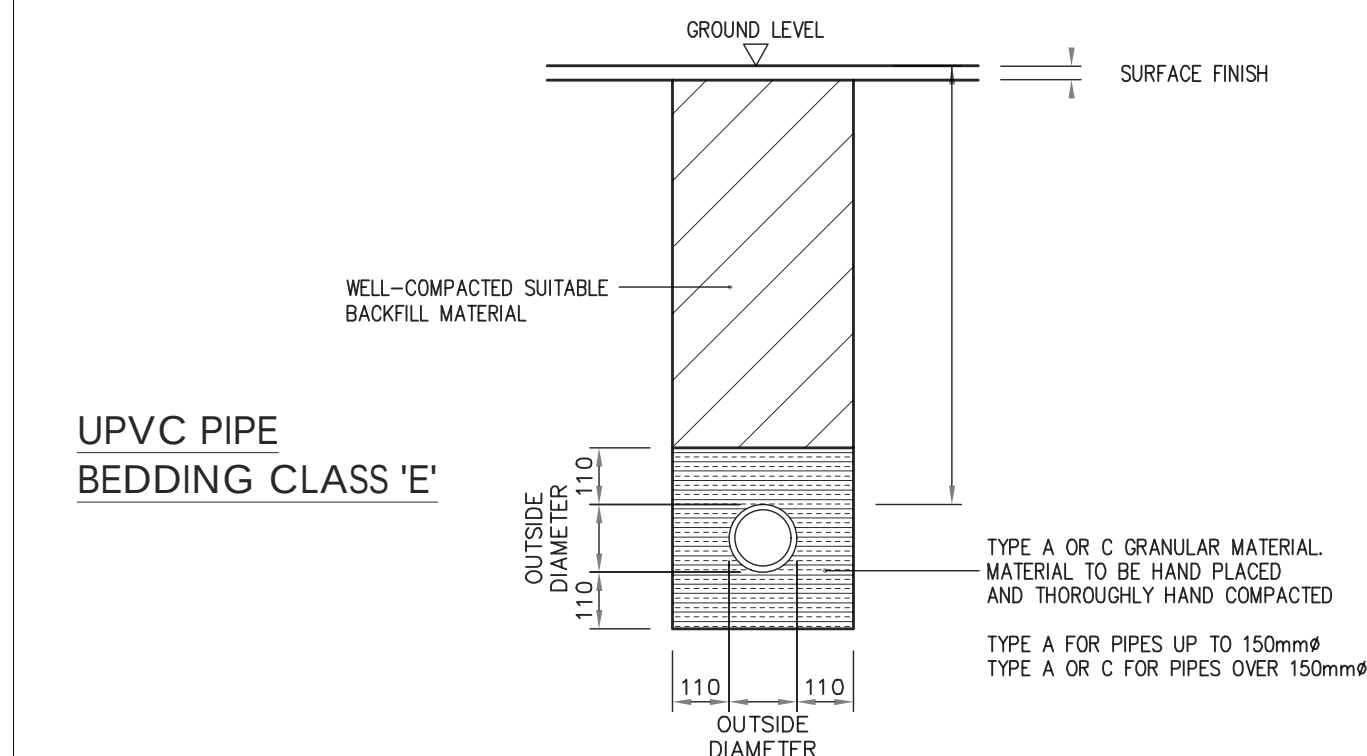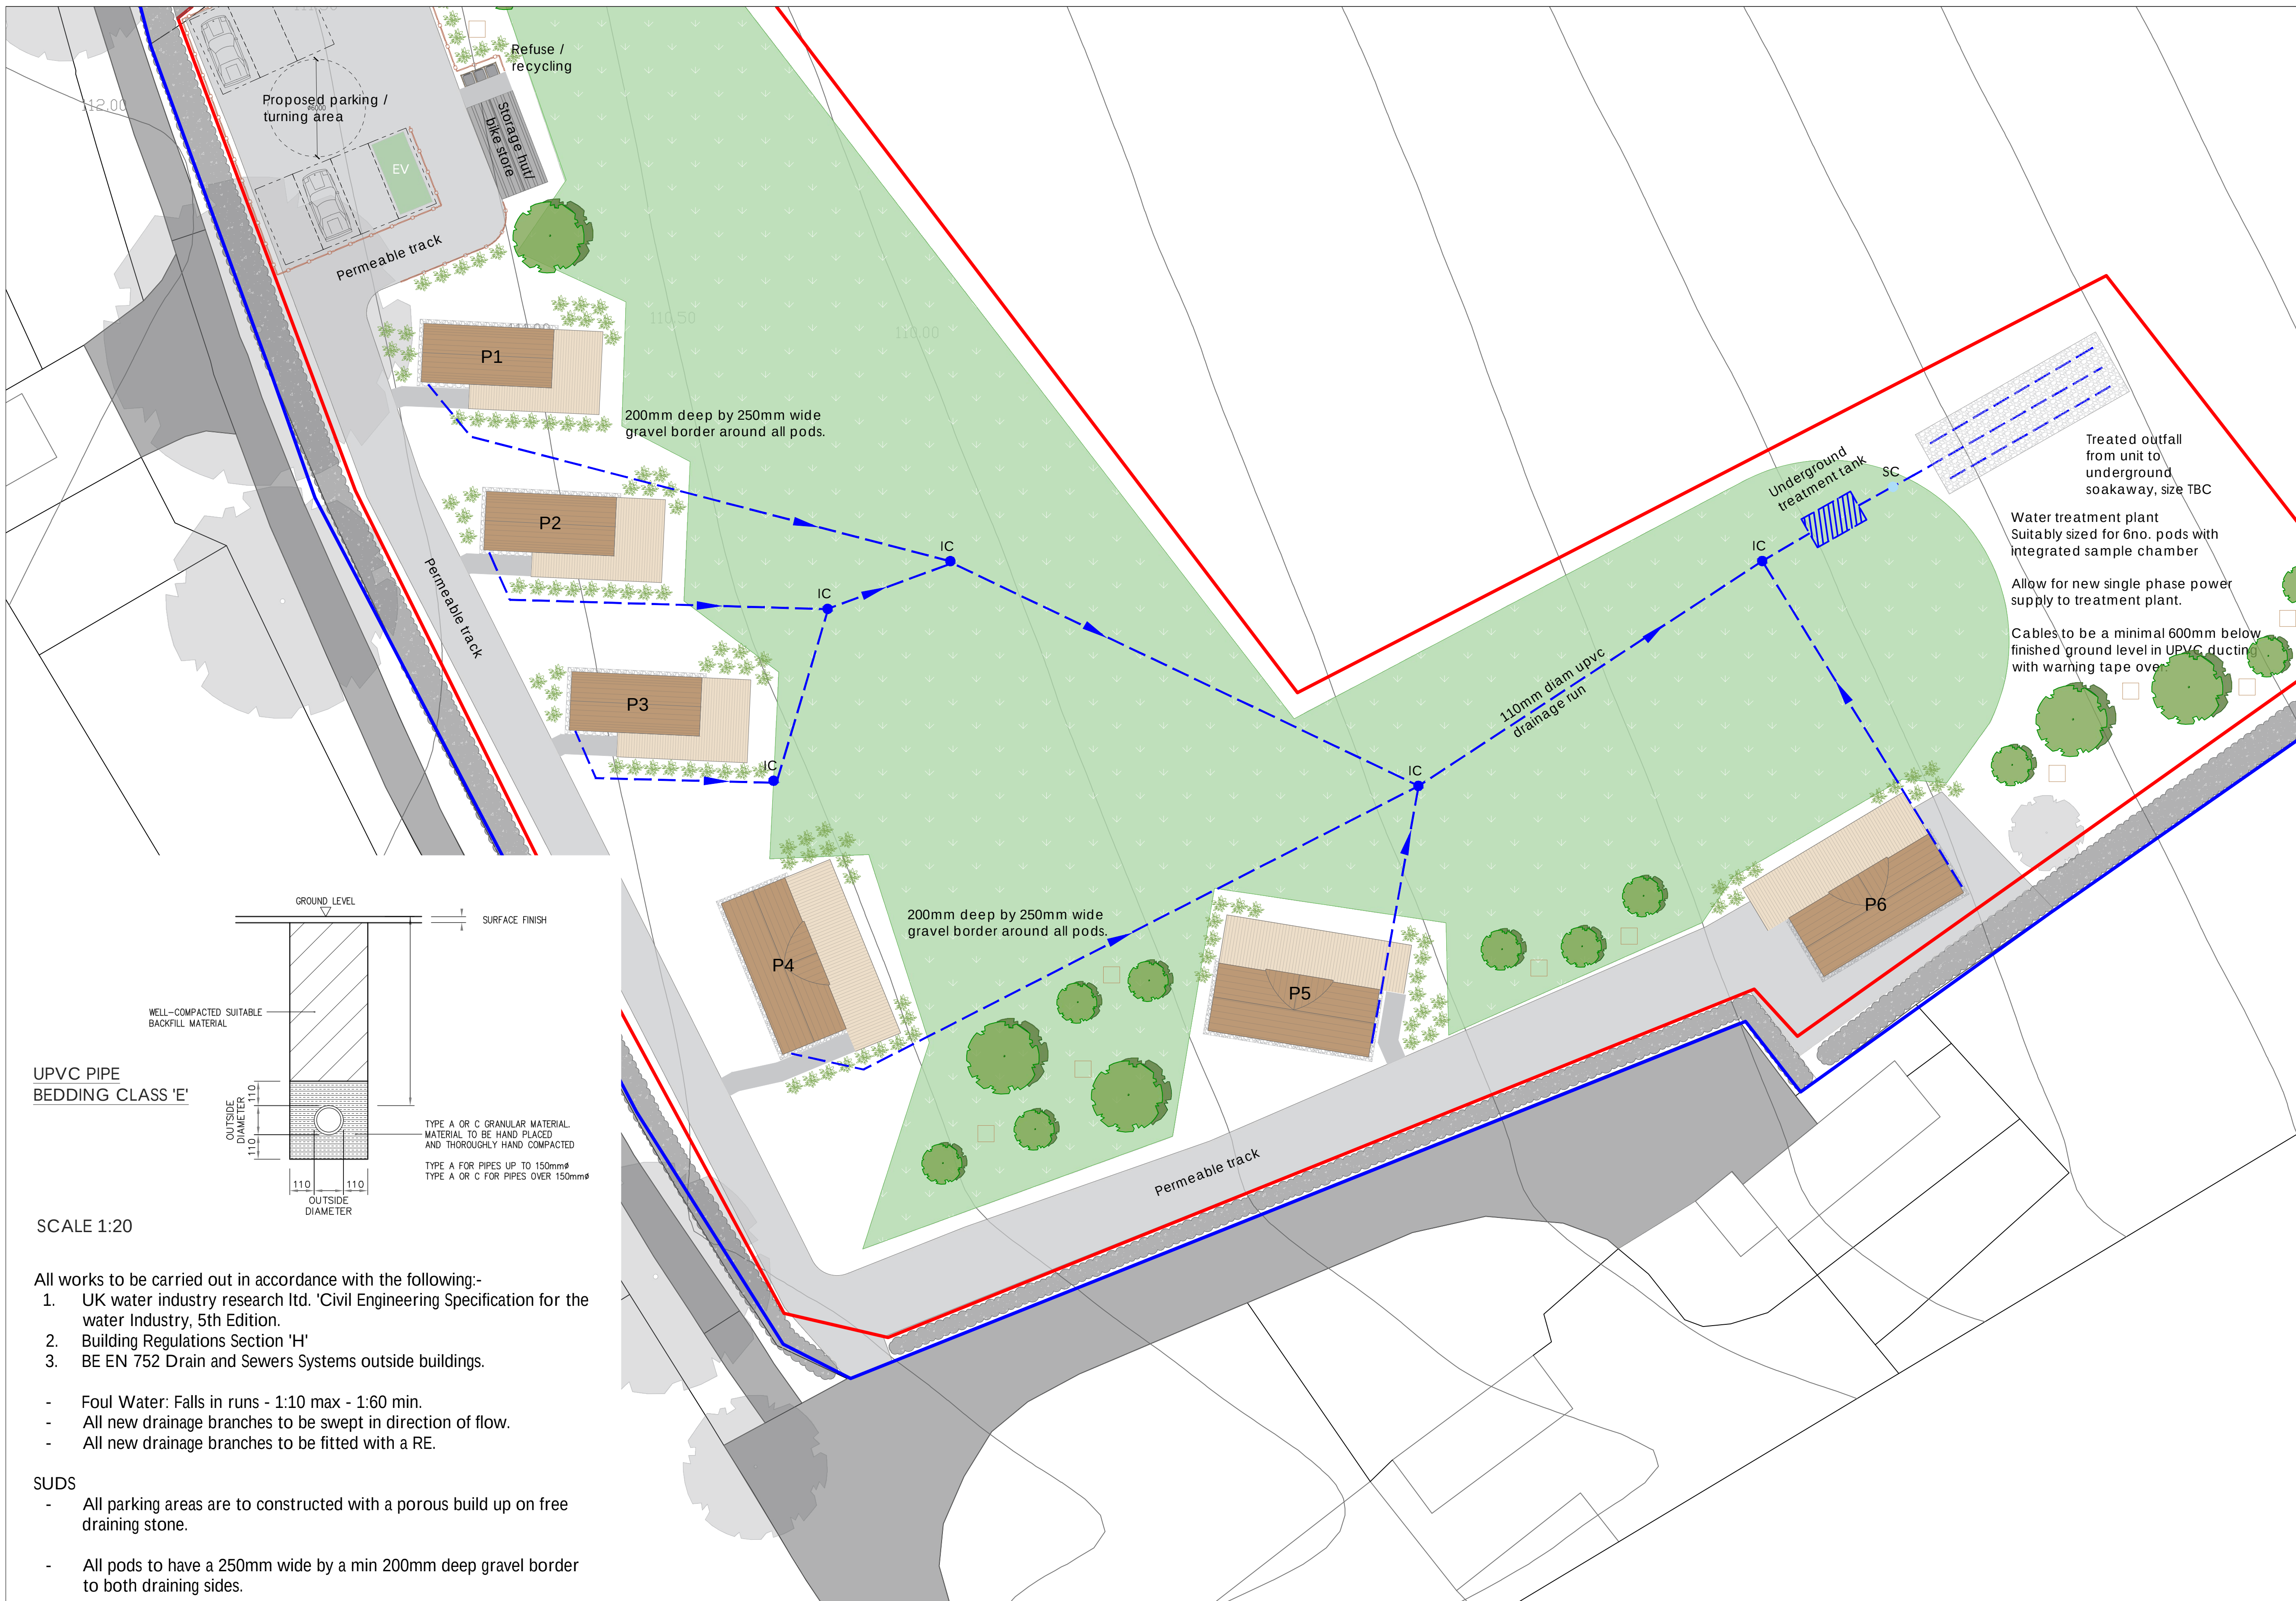

- SCALE 1:20
- All works to be carried out in accordance with the following:-
1. UK water industry research Ltd. 'Civil Engineering Specification for the water Industry, 5th Edition.
 2. Building Regulations Section 'H'
 3. BE EN 752 Drain and Sewers Systems outside buildings.
- Foul Water: Falls in runs - 1:10 max - 1:60 min.
 - All new drainage branches to be swept in direction of flow.
 - All new drainage branches to be fitted with a RE.
- SUDS
- All parking areas are to constructed with a porous build up on free draining stone.
 - All pods to have a 250mm wide by a min 200mm deep gravel border to both draining sides.

- OWNERSHIP BOUNDARY
- SITE BOUNDARY

