


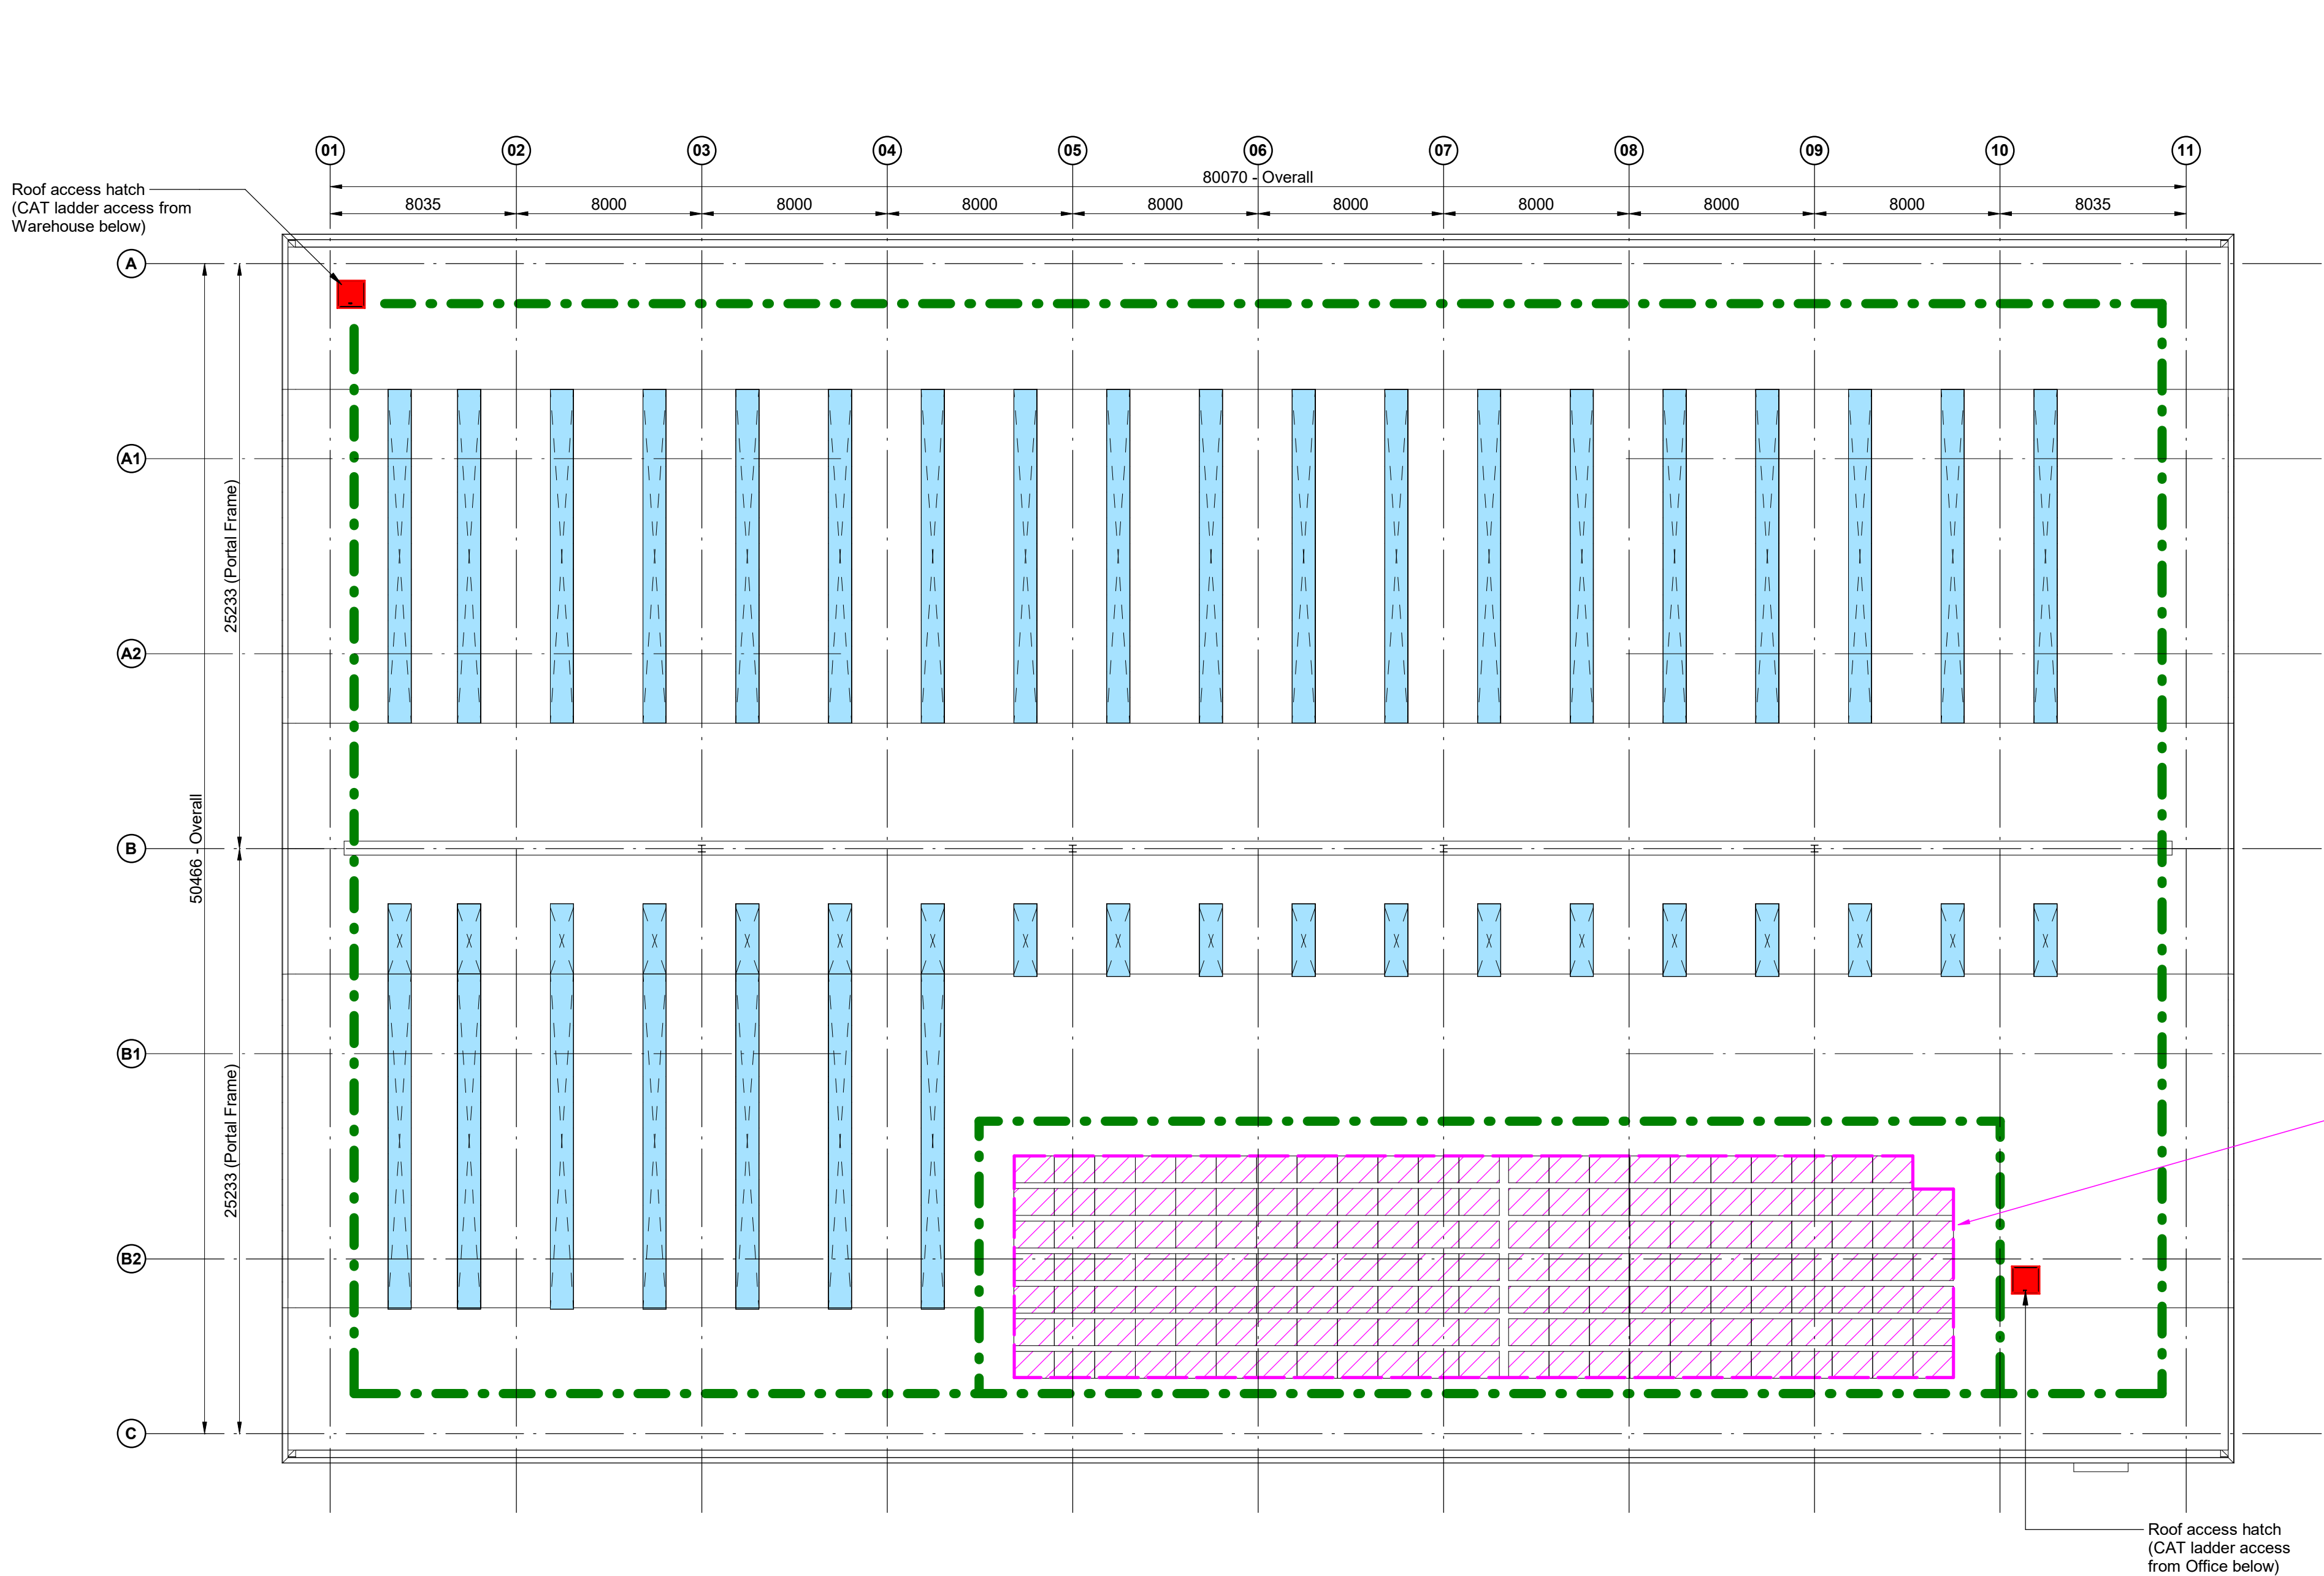

Key:



Roof access hatch
(min. 900 x 900mm clear)



Man Safe system consisting of inertia reel posts and wires.
Please refer to Access and Safety Ltd Drawing Number
P22034-HRL-U2-RL-DR-X-60200 for further details.



GRP Translucent non-fragile roof lights to a total of 10-15%
total warehouse floor area. Exact locations & clear area TBC.
U-Value to comply with part L2 calculations.

Warehouse floor area = 3,941m²
10% = 394.1m²
15% = 591.15m²



Independent Energy Group proposed PV Layout - Option 1
160 x 140w Photovoltaic Panels Providing a 65.6kWp System.
Rows to have 250mm inbetween to avoid shadowing.

Notes:

- Actual allowance may differ dependent on detailed modelling by others and PV modules utilised.
- Please refer to the latest revision of Hathaway's Drawing P22026-HRL-U2-RF-DR-X-00202-UNIT 2 OUTER SHEET PLAN for further details and information regarding rooflight setting out

Changes Key:

01 - Proposed PV layout indicated.

NOTE:

Changes highlighted are against drawing 'Unit 2 Roof Plan Drg No: 22113 P2006 Rev: D' approved on 5 May 2022 (Application No. 22/00430/FUL)

1 NMA App - Roof Plan
1 : 200

P.1 Initial Issue JB AS 17.05.23

rev amendments by ckd date

DZ3 Hinckley Park, Avery Way

Unit 2 - NMA App - Roof Plan

Information Container LOIN	
LOD 3	LOI 2



Newark Beacon, Caferata Way, Newark, Nottinghamshire, NG24 2TN
+44 (0)1636 653027 +44 (0)1636 653010 info@umcarchitects.com

RIBA PoW Stage:	Stage 4 - Technical Design
Suitability / Status:	S4
Drawn / Checked:	JB / AS
Date:	17.05.23
Scale:	1 : 200 @ A1
UMC Project Number:	22113
Document Reference:	Drawing no: Revision:
P22-034-UMC-UB-RF-DR-A-	2705 P.1

PLANNING
THIS DRAWING IS FOR PLANNING CONSIDERATION ONLY
AND SHOULD NOT BE USED FOR ANY OTHER PURPOSE

1m SCALE 1:200