


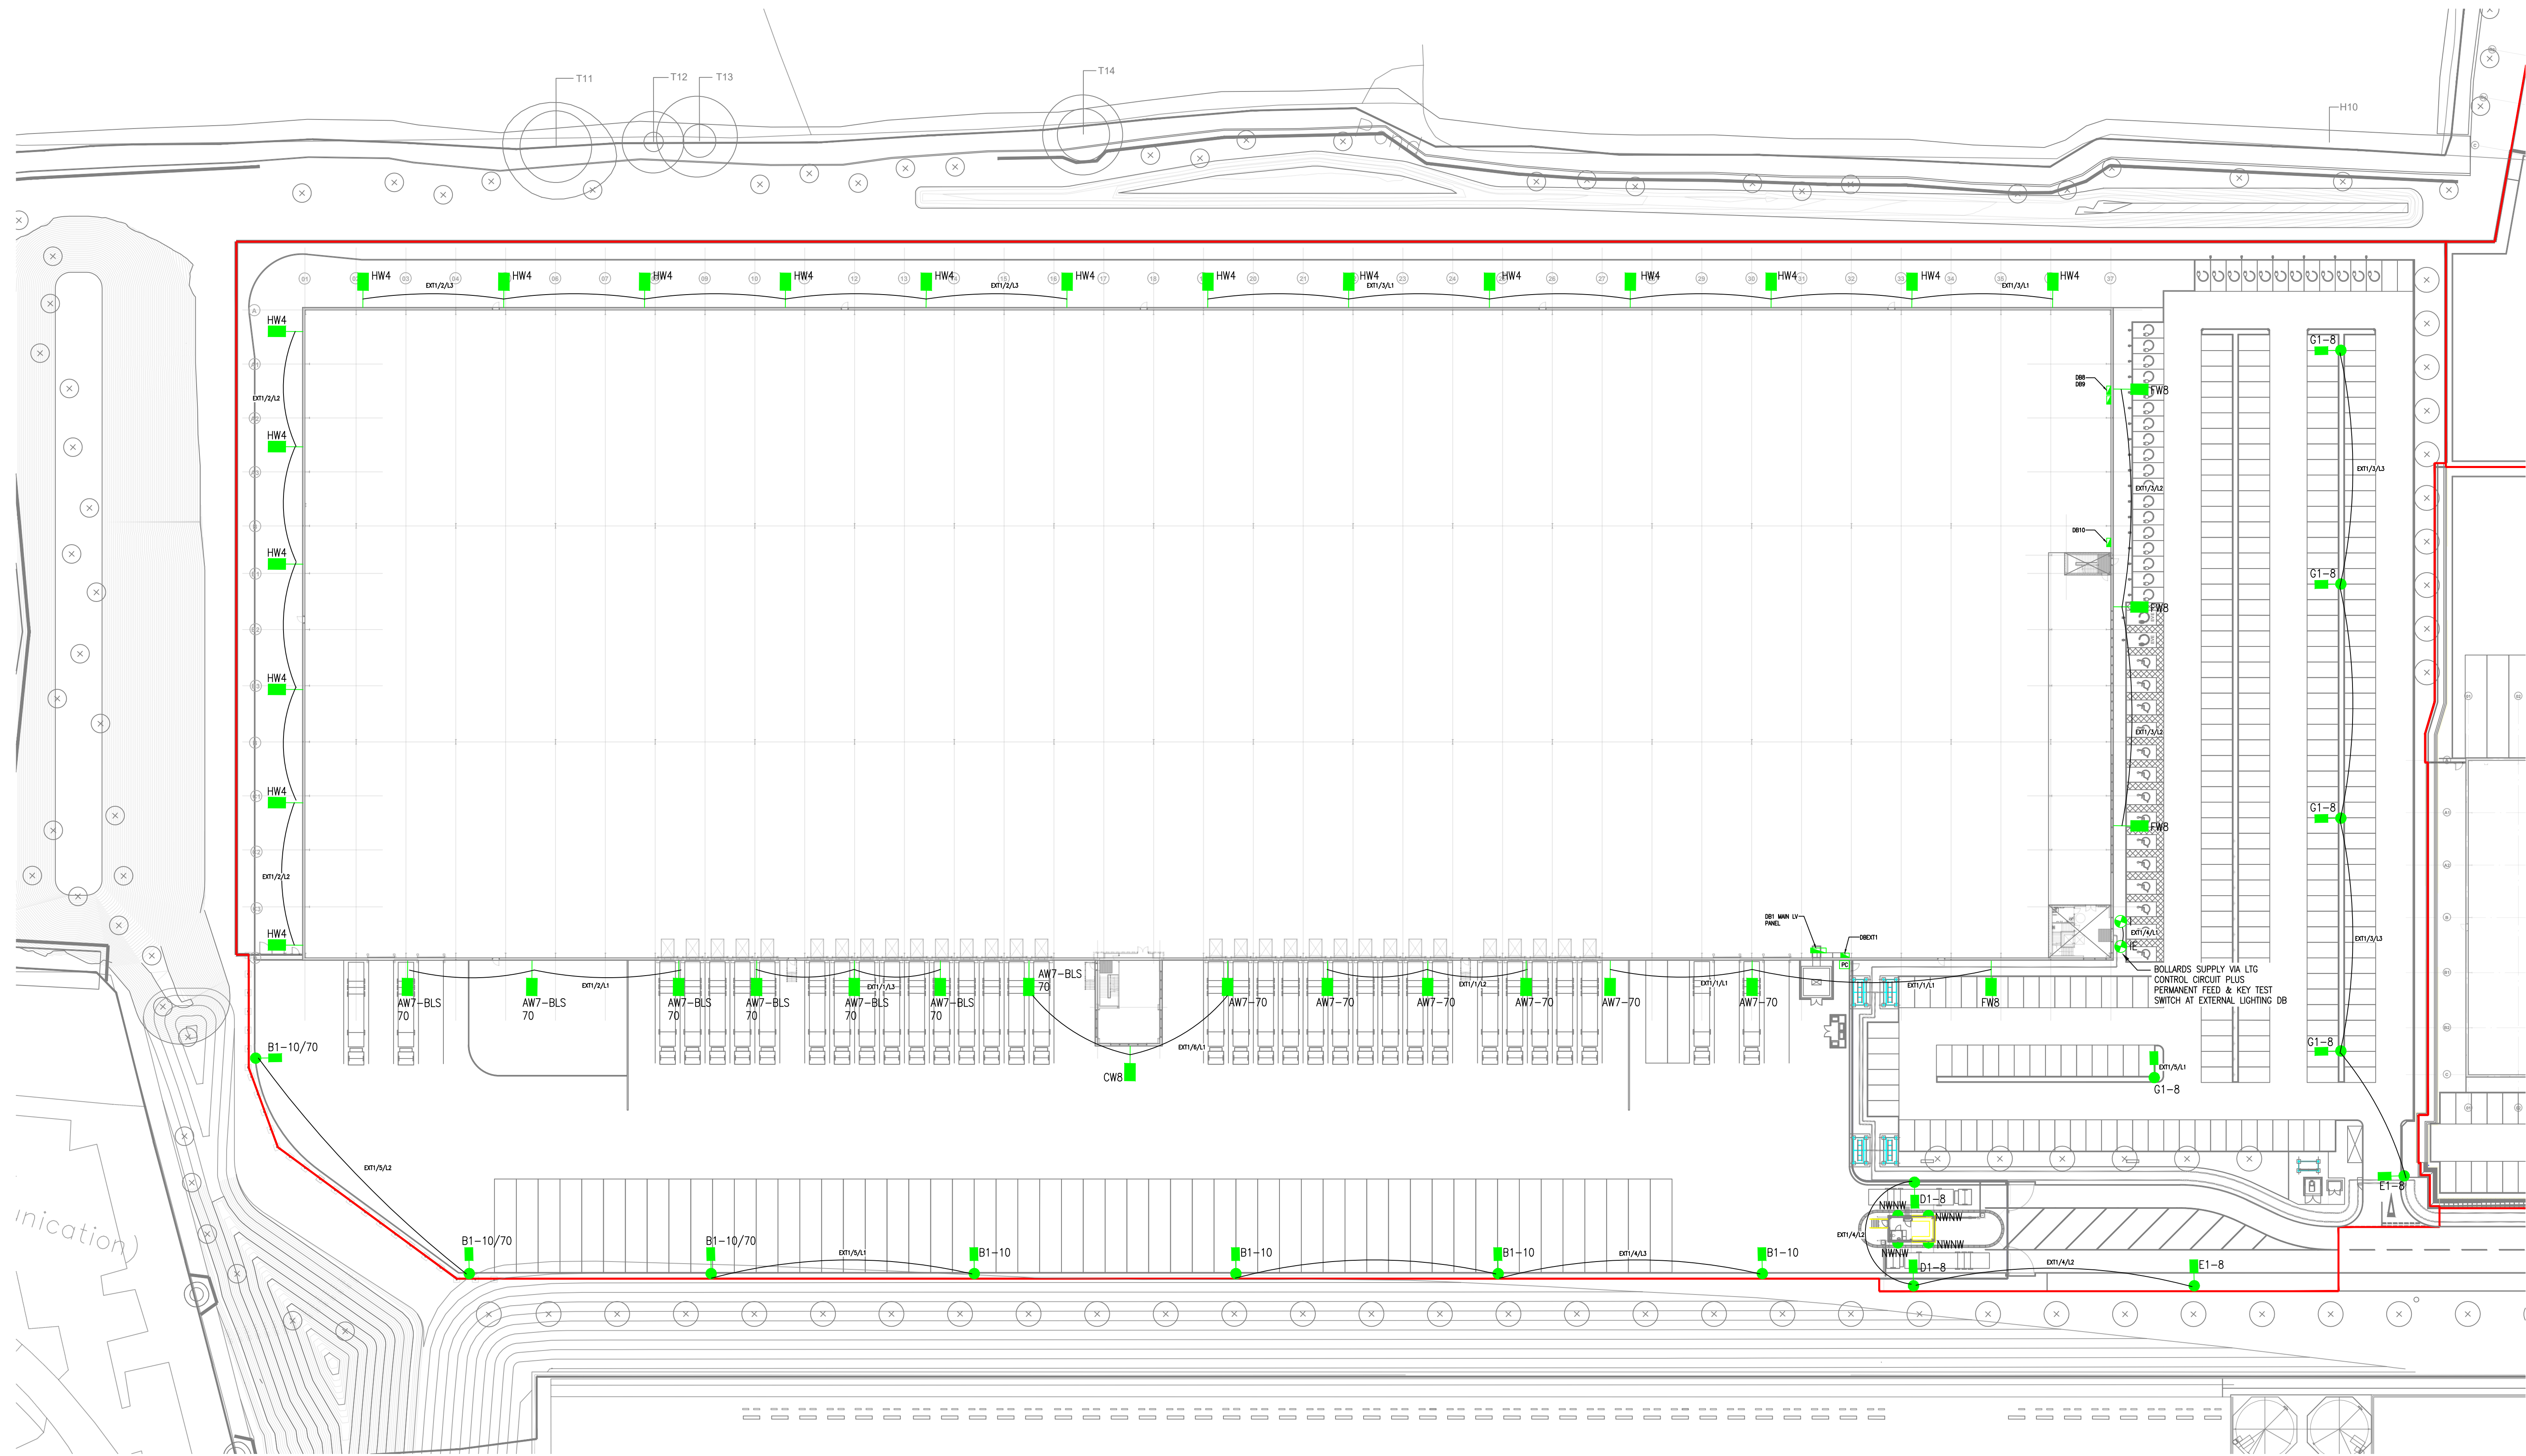

- DRAWING NOTES**
- THIS DRAWING IS TO BE READ IN CONJUNCTION WITH ALL ARCHITECTURAL, STRUCTURAL, AND ALL OTHER RELEVANT BUILDING INFORMATION DRAWINGS AND DOCUMENTATION.
 - ALL DIMENSIONS ARE IN MILLIMETERS (MM) UNLESS SPECIFICALLY DETAILED WITHIN THE LAYOUT/SUPPORTING DOCUMENTATION.
 - THE ELECTRICAL INSTALLATION SHALL COMPLY WITH THE 18TH EDITION OF THE IET WIRING REGULATIONS (BS 7671:2018) REQUIREMENTS FOR ELECTRICAL INSTALLATIONS.



- LEGEND**
- COLUMN MOUNTED ROAD LANTERN
 - BUILDING MOUNTED ROAD LANTERN
 - COLUMN
 - WALL MOUNTED AMENITY FITTING
 - BOLLARD
 - PHOTOCELL FOR EXTERNAL LIGHTING CONTROL

NOTE

TYPE "IE" BOLLARDS TO HAVE PERMANENT FEED & KEY TEST SWITCH AT EXTERNAL LIGHTING DB

Schedule					
Label	Quantity	Catalog Number	Description	Lumens Per Lamp	Light Loss Factor
J1-8	0	NML2LA024V11412.M03	Column Mounted 8m 0° Tilt	5197	1
AW8	0	DSX2.2LA364.FW	Wall Mounted 8m	40787	1
AW7-BLS-70	7	DSX2.2LA364.FW.BLS	Wall Mounted 7m, with Back Light Shield, CLO 70%	31845	0.7
A1-10	0	DSX2.2LA364.FW	Column Mounted 10m	40787	1
B1-10	4	DSX1.2LA304.FW	Column Mounted 10m	30330	1
CW8	0	DSX0.1LA114.FW	Wall Mounted 8m	11644	1
DW8	0	DSX0.1LA114.FW	Wall Mounted 8m	11644	1
CW6	1	DSX0.1LA084.FW	Wall Mounted 8m	8023	1
C1-8	0	DSX0.1LA114.FW	Column Mounted 8m	11322	1
D1-8	2	DSX1.2LA304.FW	Column Mounted 8m	29463	1
E1-8	0	DSX0.1LA084.FW	Column Mounted 6m	7802	1
E1-8	2	DSX0.1LA084.FW	Column Mounted 8m	7802	1
EW-4	0	DWL1.LA034.NE.W018	Wall Mounted 4m	2544	1
FW8	4	DSX1.2LA224.FW	Wall Mounted 8m	24252	1
F	0	DB0.1LA014.00.AY.W009	1m Bollard	932	1
G1-8	5	DSX1.2LA224.FW	Column Mounted 8m	25179	1
HW4	19	DWL1.LA034.NE.W025	Wall Mounted 4m	3779	1
I	2	DB0.1LA014.00.AY.W009	1m Bollard	932	1
AW7-70	6	DSX2.2LA364.FW	Wall Mounted 7m, CLO 70%	40787	0.7
B1-10-70	3	DSX1.2LA304.FW	Column Mounted 10m, CLO 70%	30330	0.7
A1 1-70	0	DSX2.2LA364.FW	Column Mounted 10m, CLO 70%	40787	0.7
NH	4	DENLA024.COL.NR	Wall Mounted 4m	2451	1

LOCATIONS OF COLUMNS ARE INDICATIVE ONLY. THE MAIN CONTRACTOR & ARCHITECT SHALL BE RESPONSIBLE FOR CO-ORDINATING THE FINAL LOCATIONS WITH KERB DETAILS ETC

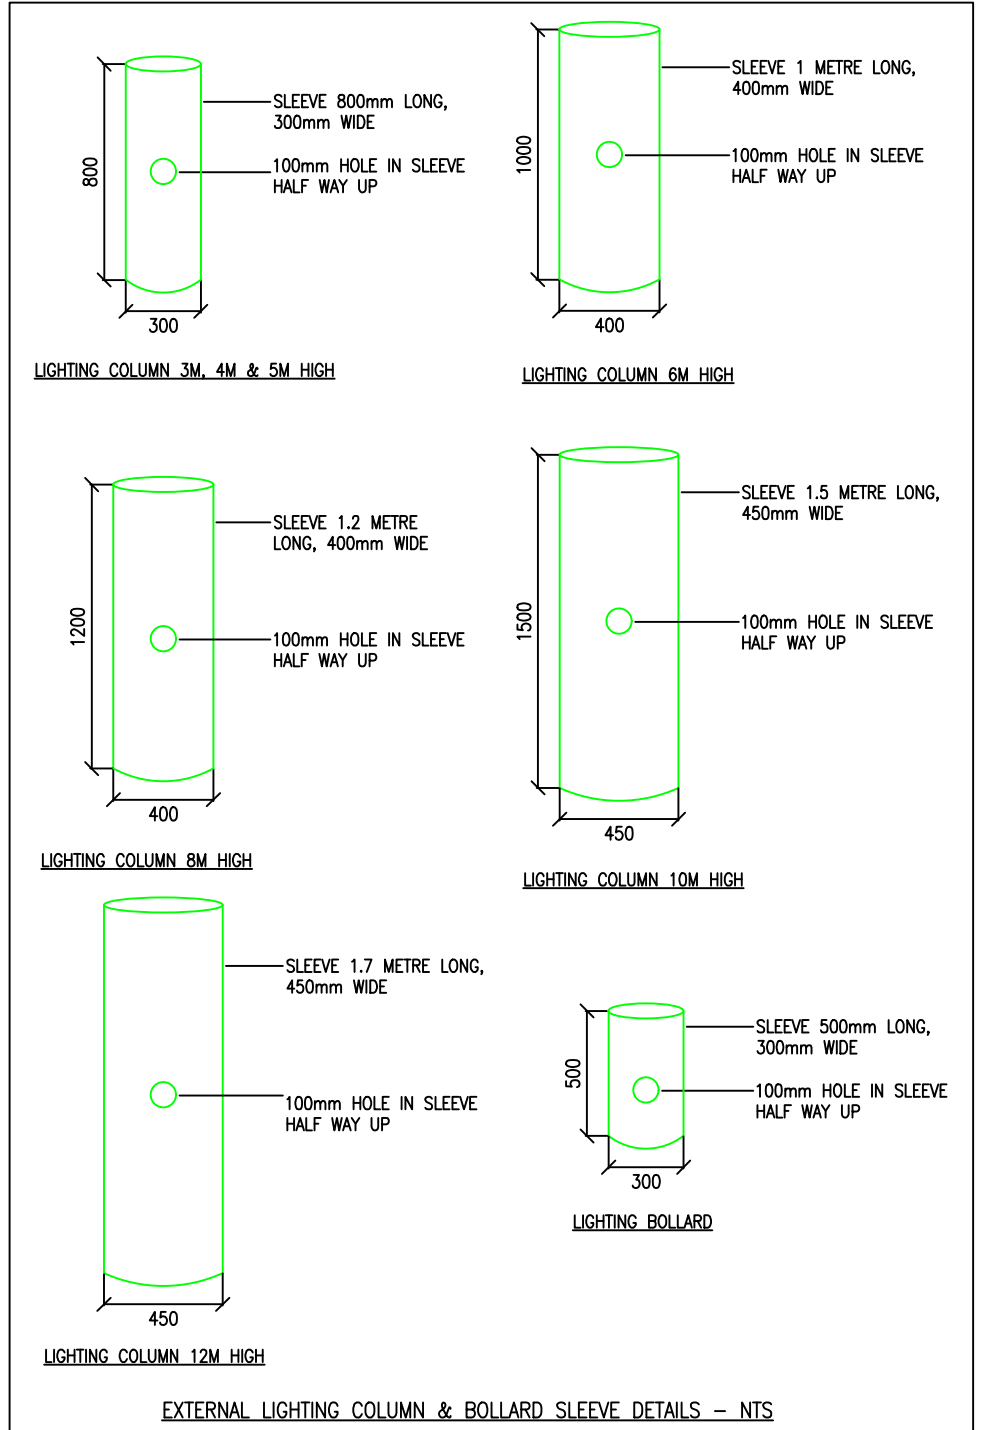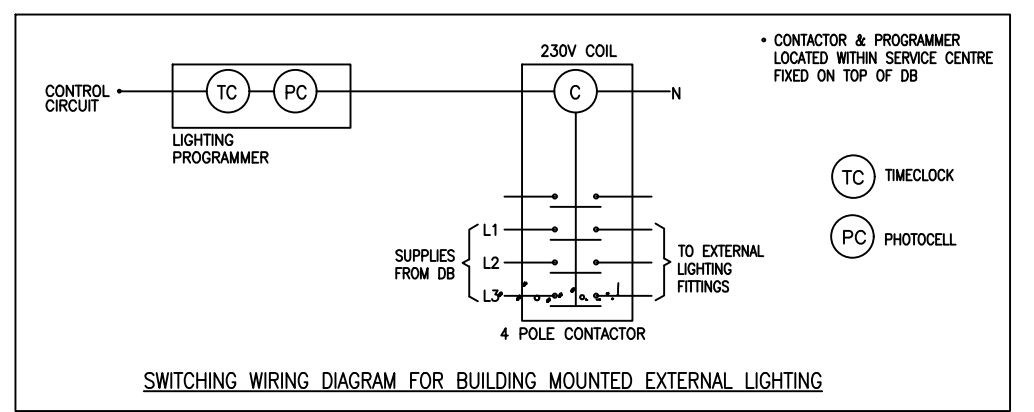

REV.	DESCRIPTION	DATE
P6	REVISED TO SUIT COMMENTS	07/06/2023
P5	REVISED TO SUIT COMMENTS	31/05/2023
P4	REVISED TO SUIT COMMENTS	16/05/2023
P3	REVISED TO SUIT COMMENTS	05/05/2023
P2	CIRCUITS ADDED	31/03/2023
P1	PRELIMINARY ISSUE	06/01/2023

PROJECT

Hinckley DZ3
Unit 1

CLIENT

winvic

TITLE

External Lighting Layout
As Proposed

DRAWN	CHECKED	DATE	SCALE
TM	MM	JUN 2023	1:500
DWG No. P22034-WME-U1-XX-DR-E-0500			
REV P6			