

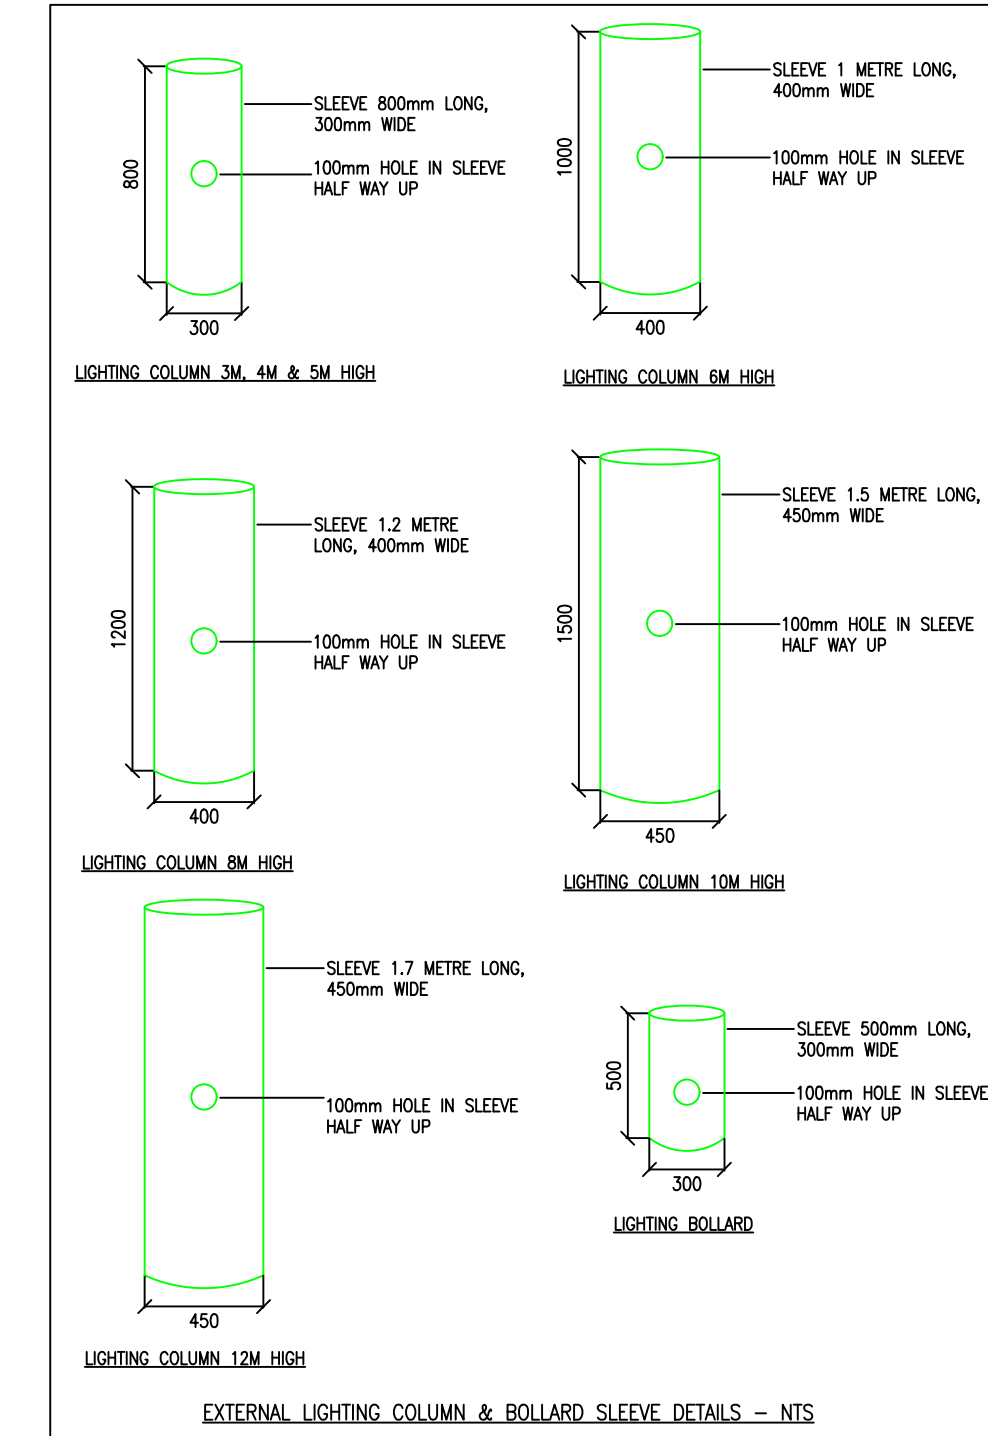


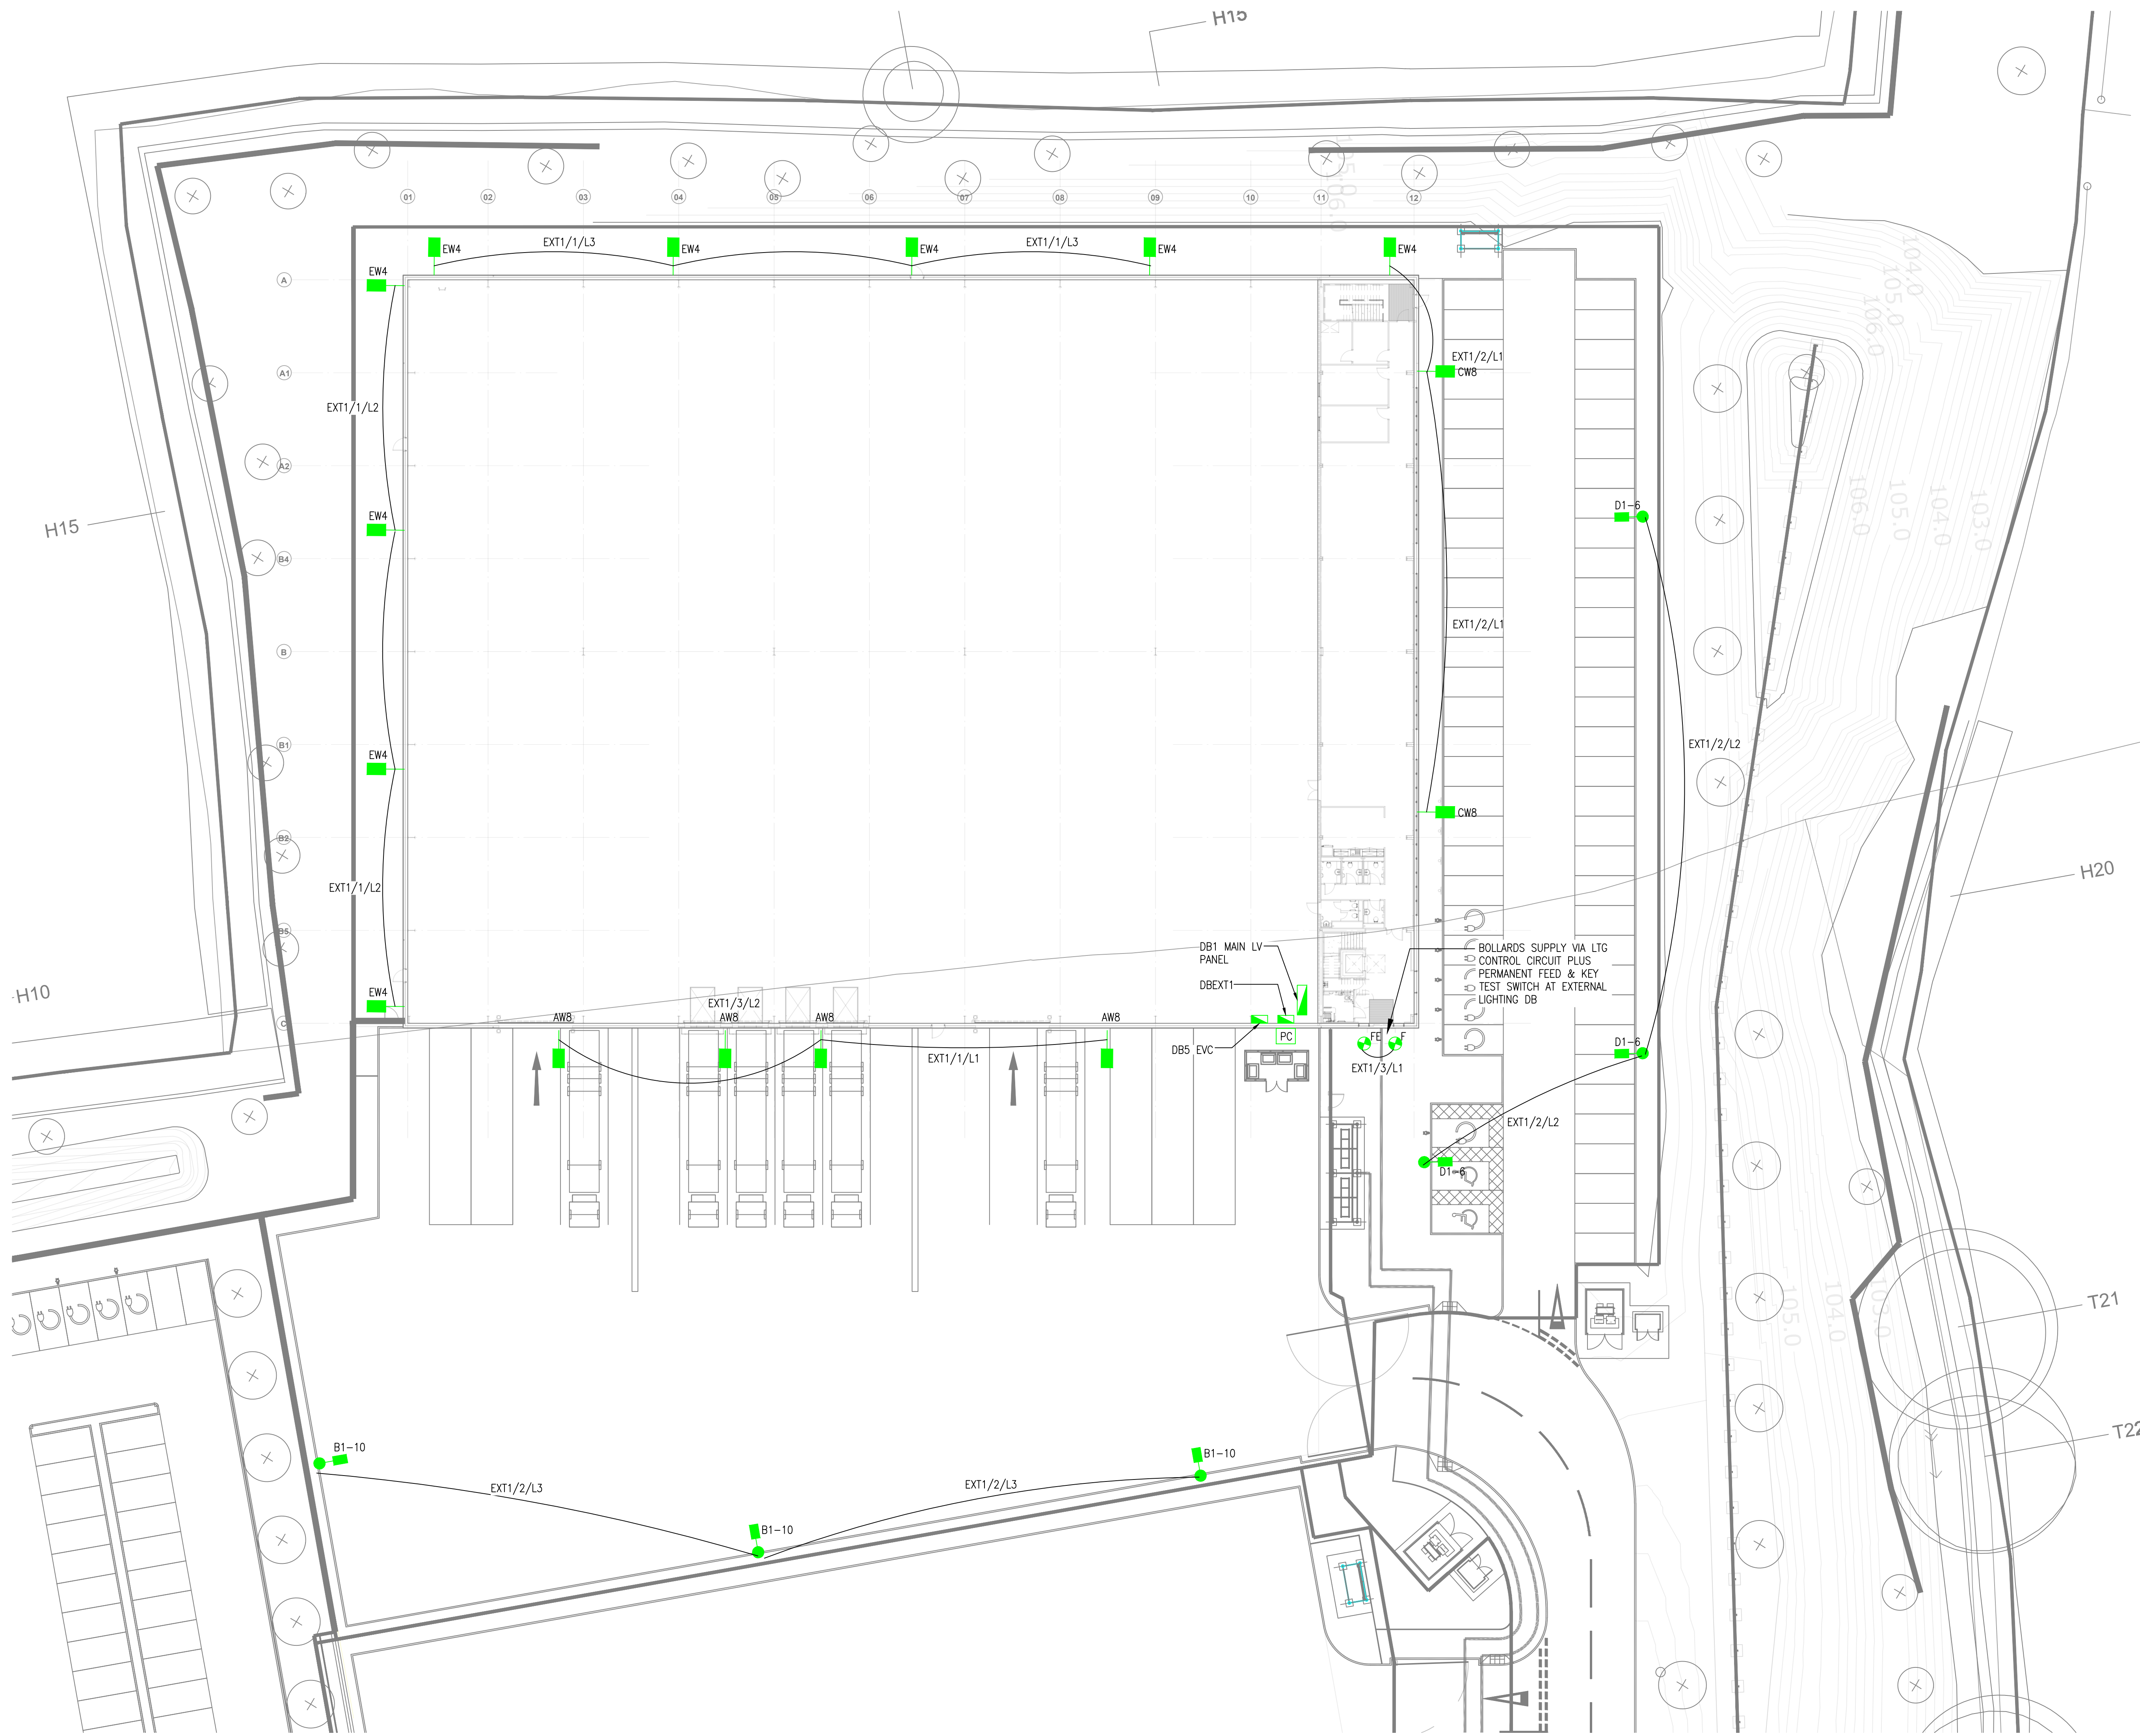

LOCATIONS OF COLUMNS ARE INDICATIVE ONLY. THE MAIN CONTRACTOR & ARCHITECT SHALL BE RESPONSIBLE FOR CO-ORDINATING THE FINAL LOCATIONS WITH KERB DETAILS ETC

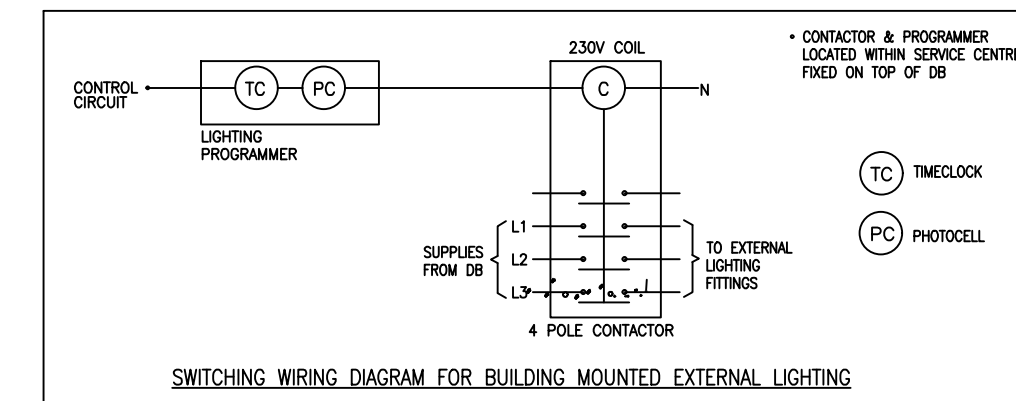

| Schedule   |          |                          |                                                    |                 |                   |         |
|------------|----------|--------------------------|----------------------------------------------------|-----------------|-------------------|---------|
| Label      | Quantity | Catalog Number           | Description                                        | Lumens Per Lamp | Light Loss Factor | Wattage |
| J1-8       | 0        | NW2.2LA264.V1.F4.2.W03.6 | Column Mounted @ 8m @ 7H                           | 5197            | 1                 | 36      |
| AW8        | 4        | DSX2.2LA364.FW           | Wall Mounted @ 8m                                  | 40787           | 1                 | 328     |
| AW7-BLS-70 | 0        | DSX2.2LA364.FW.BLS       | Wall Mounted @ 7m, with Back Light Shield, CLO 70% | 31845           | 0.7               | 328     |
| A1-10      | 0        | DSX2.2LA364.FW           | Column Mounted @ 10m                               | 40787           | 1                 | 328     |
| B1-10      | 3        | DSX1.2LA304.FW           | Column Mounted @ 10m                               | 30330           | 1                 | 286     |
| CWS        | 2        | DSX0.1LA114.FW           | Wall Mounted @ 8m                                  | 11644           | 1                 | 88      |
| DWS        | 0        | DSX0.1LA114.FW           | Wall Mounted @ 8m                                  | 11644           | 1                 | 88      |
| CWS        | 0        | DSX0.1LA084.FW           | Wall Mounted @ 8m                                  | 8023            | 1                 | 64      |
| C1-8       | 0        | DSX0.1LA114.AY           | Column Mounted @ 8m                                | 11322           | 1                 | 88      |
| D1-8       | 0        | DSX1.2LA304.AY           | Column Mounted @ 8m                                | 29463           | 1                 | 286     |
| D1-6       | 3        | DSX0.1LA084.AY           | Column Mounted @ 6m                                | 7802            | 1                 | 64      |
| E1-8       | 0        | DSX0.1LA084.AY           | Column Mounted @ 8m                                | 7802            | 1                 | 64      |
| EW-4       | 9        | DWL1.LA034.NR.W018       | Wall Mounted @ 4m                                  | 2544            | 1                 | 18      |
| FW8        | 0        | DSX1.2LA224.FW           | Wall Mounted @ 8m                                  | 24252           | 1                 | 200     |
| F          | 2        | DBD.1LA014.D0.AY.W009    | 1m Bollard                                         | 832             | 1                 | 9       |
| G1-8       | 0        | DSX1.2LA224.SY           | Column Mounted @ 8m                                | 25179           | 1                 | 200     |
| HWS        | 0        | NW1.LA054.AY             | Wall Mounted @ 5m                                  | 4922            | 1                 | 42      |
| I          | 0        | DBD.1LA014.D0.AY.W009    | 1m Bollard                                         | 832             | 1                 | 9       |
| AW7-70     | 0        | DSX2.2LA364.FW           | Wall Mounted @ 7m, CLO 70%                         | 40787           | 0.7               | 328     |
| B1-10-70   | 0        | DSX1.2LA304.FW           | Column Mounted @ 10m, CLO 70%                      | 30330           | 0.7               | 286     |
| A1 Y-70    | 0        | DSX2.2LA364.FW           | Column Mounted @ 10m, CLO 70%                      | 40787           | 0.7               | 328     |

- DRAWING NOTES**
- THIS DRAWING IS TO BE READ IN CONJUNCTION WITH ALL ARCHITECTURAL, STRUCTURAL, AND ALL OTHER RELEVANT BUILDING INFORMATION DRAWINGS AND DOCUMENTATION.
  - ALL DIMENSIONS ARE IN MILLIMETERS (MM) UNLESS SPECIFICALLY DETAILED WITHIN THE LAYOUT/SUPPORTING DOCUMENTATION.
  - THE ELECTRICAL INSTALLATION SHALL COMPLY WITH THE 18TH EDITION OF THE IET WIRING REGULATIONS (BS 7671:2018) REQUIREMENTS FOR ELECTRICAL INSTALLATIONS.

**LEGEND**

- COLUMN MOUNTED ROAD LANTERN
- BUILDING MOUNTED ROAD LANTERN
- COLUMN
- WALL MOUNTED AMENITY FITTING
- BOLLARD
- PC PHOTOCELL FOR EXTERNAL LIGHTING CONTROL

**NOTE**

TYPE "TET" BOLLARDS TO HAVE PERMANENT FEED & KEY TEST SWITCH AT EXTERNAL LIGHTING DB

|    |                          |            |
|----|--------------------------|------------|
| P7 | REVISED TO SUIT COMMENTS | 07/06/2023 |
| P6 | REVISED TO SUIT COMMENTS | 31/05/2023 |
| P5 | REVISED TO SUIT COMMENTS | 16/05/2023 |
| P4 | REVISED TO SUIT COMMENTS | 11/05/2023 |
| P3 | REVISED TO SUIT COMMENTS | 05/05/2023 |
| P2 | CIRCUITS ADDED           | 08/03/2023 |
| P1 | PRELIMINARY ISSUE        | 06/01/2023 |

| REV.                                                                                                                                                   | DESCRIPTION | DATE |
|--------------------------------------------------------------------------------------------------------------------------------------------------------|-------------|------|
| <b>WALTER MILES</b><br>ELECTRICAL ENGINEERS LIMITED<br>Marshall House, Clarendon<br>Lancaster, LA3 8DT<br>Tel: (01524) 2872400<br>Fax: (01524) 2872552 |             |      |
| EST 1928                                                                                                                                               |             |      |

|                                          |
|------------------------------------------|
| <b>PROJECT</b><br>Hinckley DZ3<br>Unit 3 |
|------------------------------------------|

|                         |
|-------------------------|
| <b>CLIENT</b><br>winvic |
|-------------------------|

|                                                         |
|---------------------------------------------------------|
| <b>TITLE</b><br>External Lighting Layout<br>As Proposed |
|---------------------------------------------------------|

| DRAWN                                        | CHECKED          | DATE     | SCALE    |
|----------------------------------------------|------------------|----------|----------|
| TM                                           | MM               | JUN 2023 | 1:250@A0 |
| <b>DWG No.</b><br>P22034-WME-U3-XX-DR-E-0500 | <b>REV</b><br>P7 |          |          |