



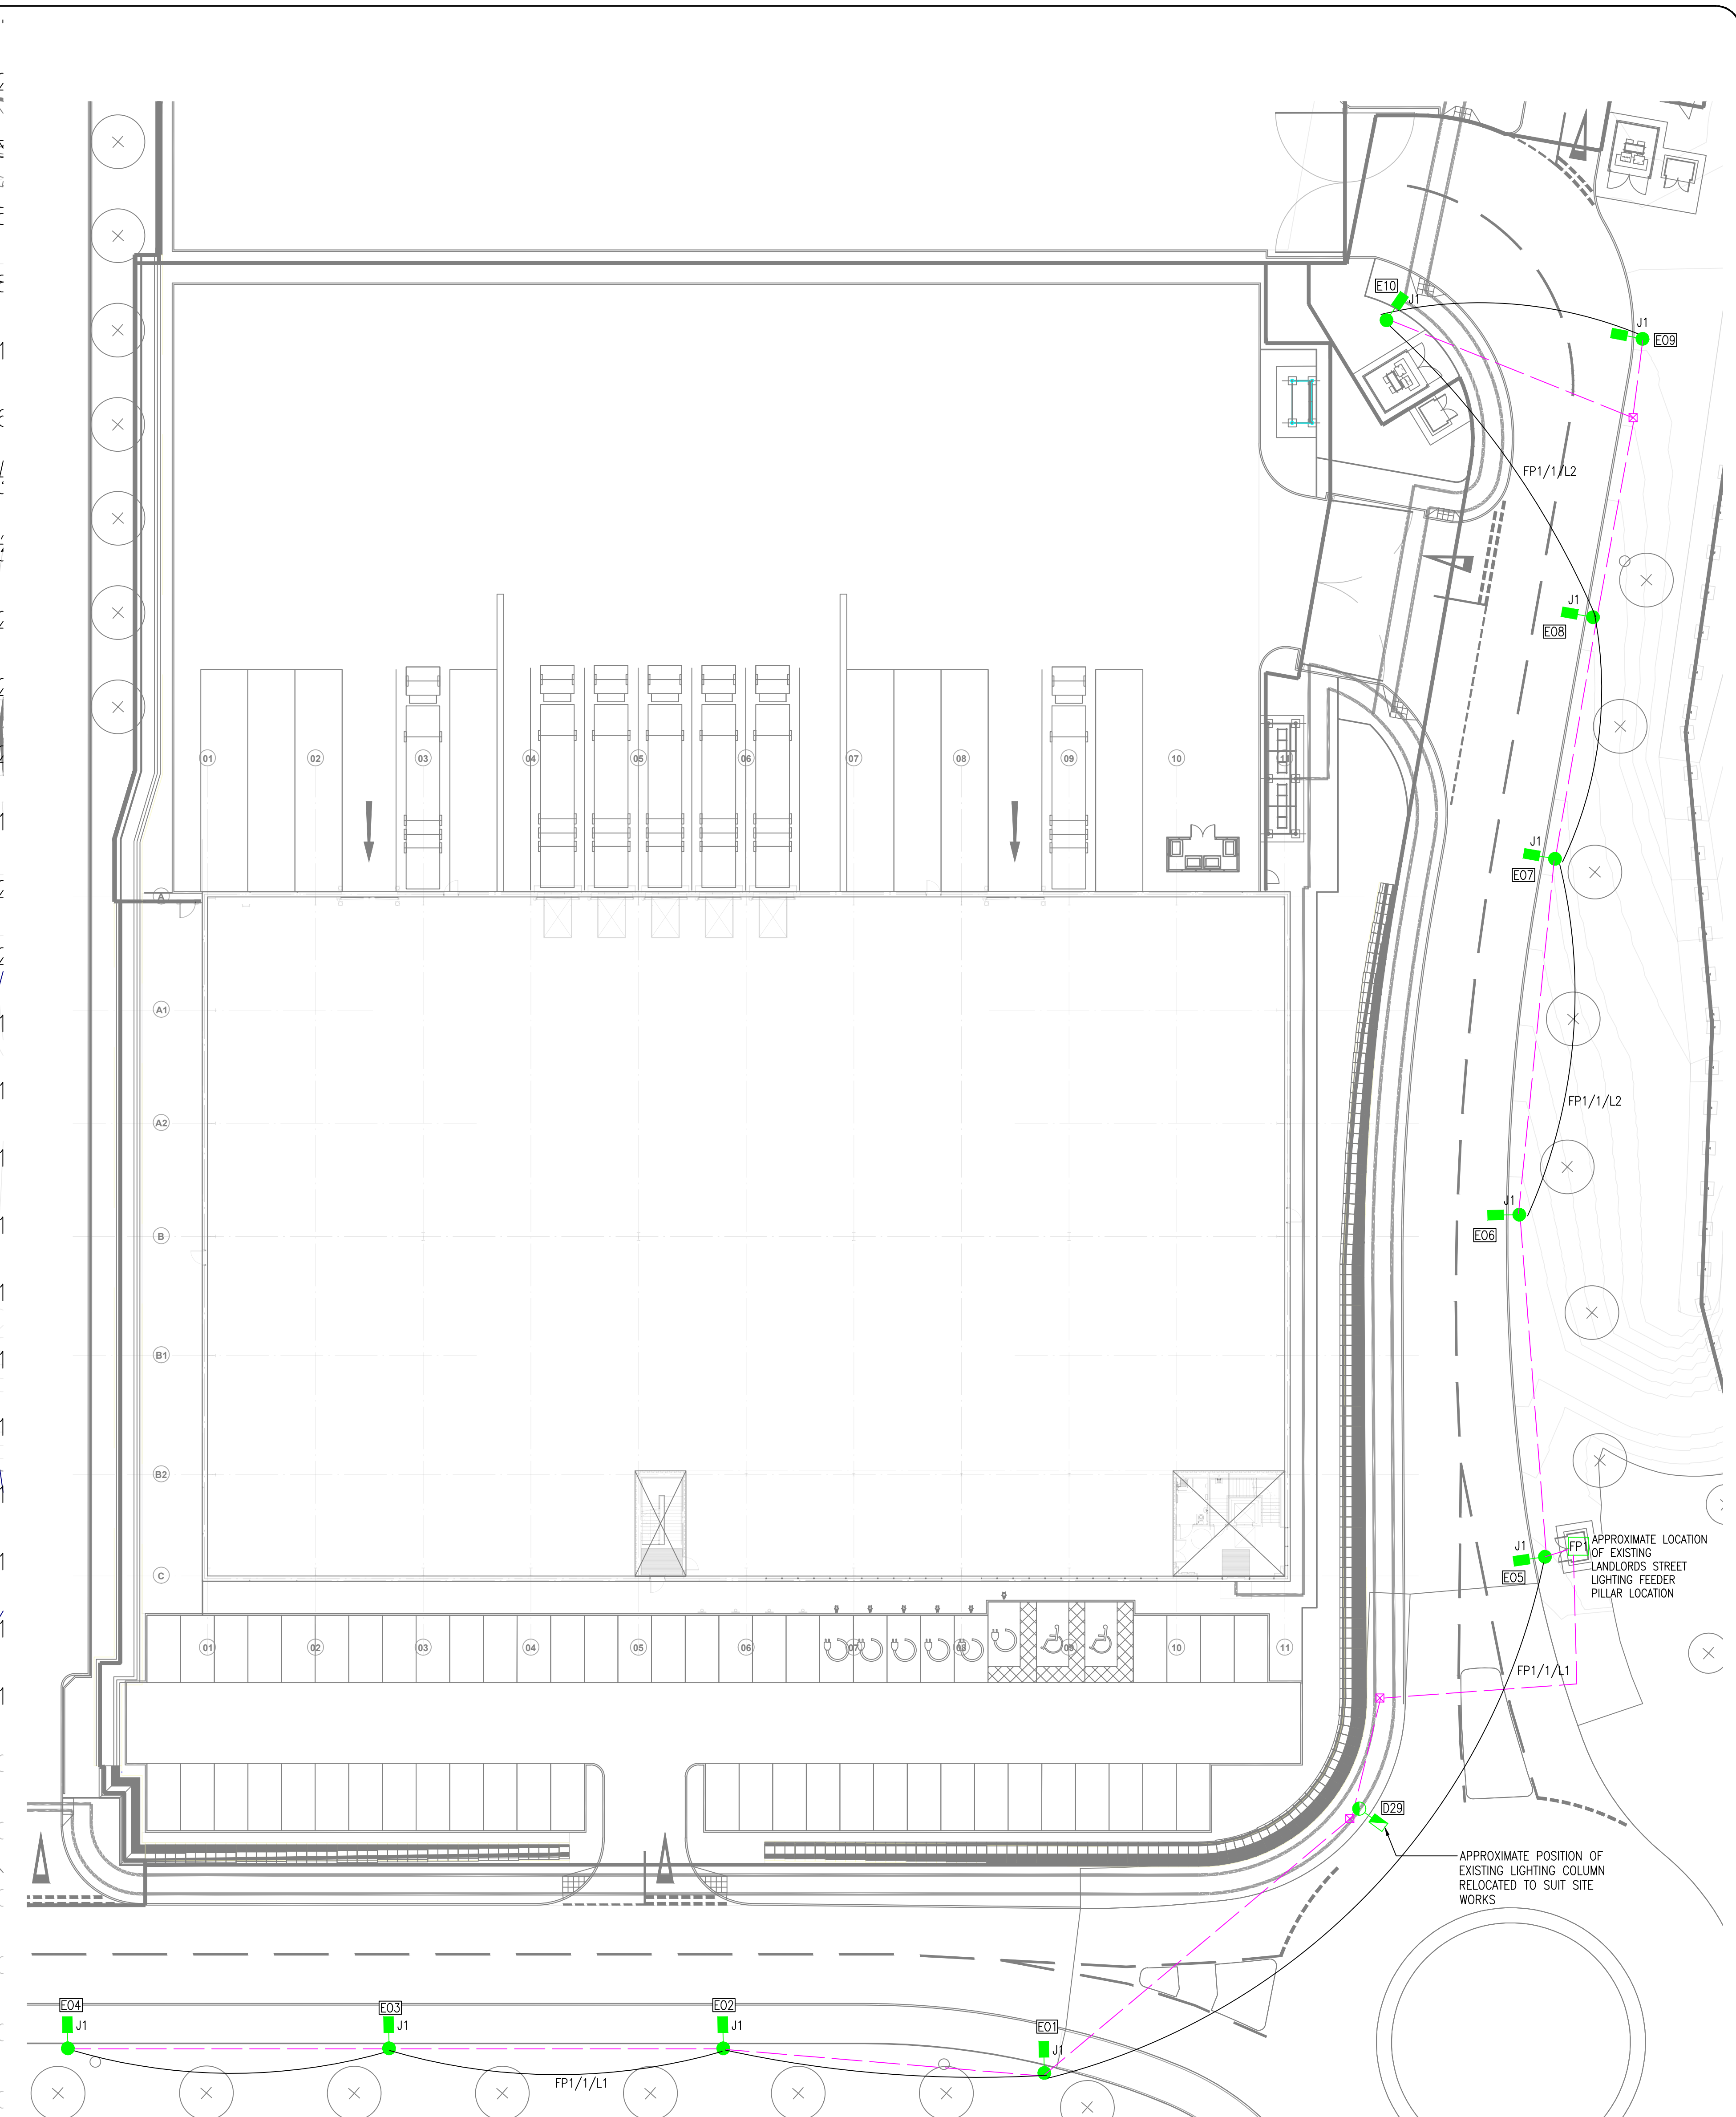

Statistics					
Description	Symbol	Avg	Max	Min	Min/Avg
Unit 2 Access Road East	+	14 lux	23 lux	6 lux	0.42
Unit 2 Access Road South 1080.4	+	12 lux	18 lux	5 lux	0.42
Unit 2 Path East	+	9 lux	18 lux	4 lux	0.44
Unit 2 South Path	+	9 lux	19 lux	3 lux	0.33
Vertical @ Inn @10m	+	0 lux	0 lux	0 lux	N/A
Vertical @ Inn @10m	+	0 lux	0 lux	0 lux	N/A
Vertical @ Inn @10m	+	0 lux	0 lux	0 lux	N/A
Vertical @ Inn @10m	+	0 lux	0 lux	0 lux	N/A
Vertical @ Inn @10m	+	0 lux	0 lux	0 lux	N/A
Vertical @ Inn @10m	+	0 lux	0 lux	0 lux	N/A
Vertical @ Inn @10m	+	0 lux	0 lux	0 lux	N/A
Vertical @ Inn	+	0 lux	0 lux	0 lux	N/A
Horizontal spill	+	1 lux	15 lux	0 lux	0.00

-

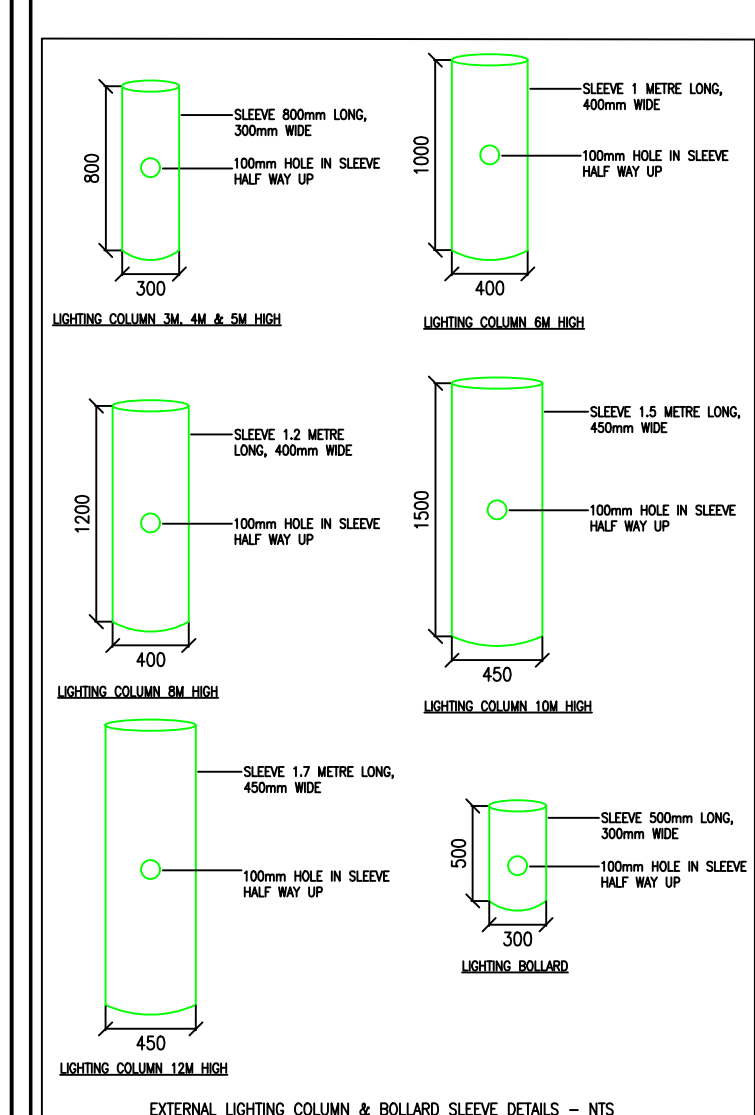

LOCATIONS OF COLUMNS ARE INDICATIVE ONLY. THE MAIN CONTRACTOR & ARCHITECT SHALL BE RESPONSIBLE FOR CO-ORDINATING THE FINAL LOCATIONS WITH KERB DETAILS ETC

P9	REVISED TO SUIT COMMENTS	07/06/2023
P8	REVISED TO SUIT UMC DRAWING	22/05/2023
P7	P22034-XXXX-SI-DR-9995 REV P1	
P6	CIRCUITS ADDED	22/05/2023
P6	REVISED TO SUIT COMMENTS	16/05/2023
P5	REVISED TO SUIT COMMENTS	16/05/2023
P4	FITTING REFERENCES ADDED	11/05/2023
P3	EXISTING COLUMN ADDED	11/04/2023
P2	REVISED TO SUIT COMMENTS	13/02/2023
P1	PRELIMINARY ISSUE	07/02/2023

WM **WALTER MILES**
ELECTRICAL ENGINEERS LIMITED

Marshall House, Glenfield
Leicester. LE3 8DT

Tel: (0116) 2872400

EST 1928

PROJECT
Hinckley DZ3
Infrastructure

CLIENT  **winvic**

TITLE
External Landlords Roadway Lighting Layout As Proposed

DRAWN TM	CHECKED MH	DATE FEB 2023	SCALE 1:250=1"0
DRG No. P22034-WME-XX-XX-DR-E-0505			REV. P9