


DO NOT SCALE FROM THIS DRAWING

This drawing is the copyright and the property of Ohmega Electrical Limited.
Copying of the design drawings or the intellectual property in full or in part is not permitted without the written consent of a Director of Ohmega Electrical Limited.
In the event of a default by the Employer of its obligations due to Ohmega Electrical Limited, neither it or its Assignees or Beneficiaries are permitted or licensed to use or copy this information until such time as the Employer has remedied its default and Ohmega Electrical has given written consent to reinstatement of its permission or licence to use its material.

The initial feasibility pre-contract designs, specifications, cost plans, bill of quantities, and all other documents or media whether electronic or hard copy are indicative only and could be subject to changes in statute or other rules regulations and changes in the Employer's requirements and will be subject to design development until such time Ohmega services are engaged under a formal written appointment that pays for an appropriate fee at commercial rates.

Use of these documents or media shall be entirely at the risk of the person using it. No reliance on these documents shall be permitted and fully copyright is retained by Ohmega Electrical Limited. Ohmega accepts no responsibility for reliance on these documents or media and it is assumed that the Contractor or Developer Client has made sufficient provision for design development risk where a full design has not been commissioned. No waiver of this endorsement shall be permitted except in writing and signed by a Director of Ohmega Electrical as recorded at Companies House.

FAN SCHEDULE							
REFERENCE	LOCATION	DESCRIPTION	MANUFACTURER	MODEL REF	FLOW RATE	PRESSURE	CONTROLS
HRU 01	PLANT MEZZANINE (FOH)	HEAT RECOVERY UNIT	DAIKIN	VAM1000J8	270 l/s	90 Pa	LOCAL CONTROLLER
HRU 02	PLANT MEZZANINE (FOH)	HEAT RECOVERY UNIT	DAIKIN	VAM1000J8	270 l/s	90 Pa	LOCAL CONTROLLER
HRU 03	PLANT MEZZANINE (FOH)	HEAT RECOVERY UNIT	DAIKIN	VAM1000J8	270 l/s	90 Pa	LOCAL CONTROLLER
HRU 04	PLANT MEZZANINE (BOH)	HEAT RECOVERY UNIT	DAIKIN	VAM1000J8	270 l/s	90 Pa	LOCAL CONTROLLER
SF 01	BAKERY	BAKERY MAKE-UP	CONTRACTORS	PREFERENCE	290 l/s	80 Pa	LOCAL CONTROLLER
EF 01	BAKERY	BAKERY EXTRACT	CONTRACTORS	PREFERENCE	290 l/s	80 Pa	LOCAL CONTROLLER

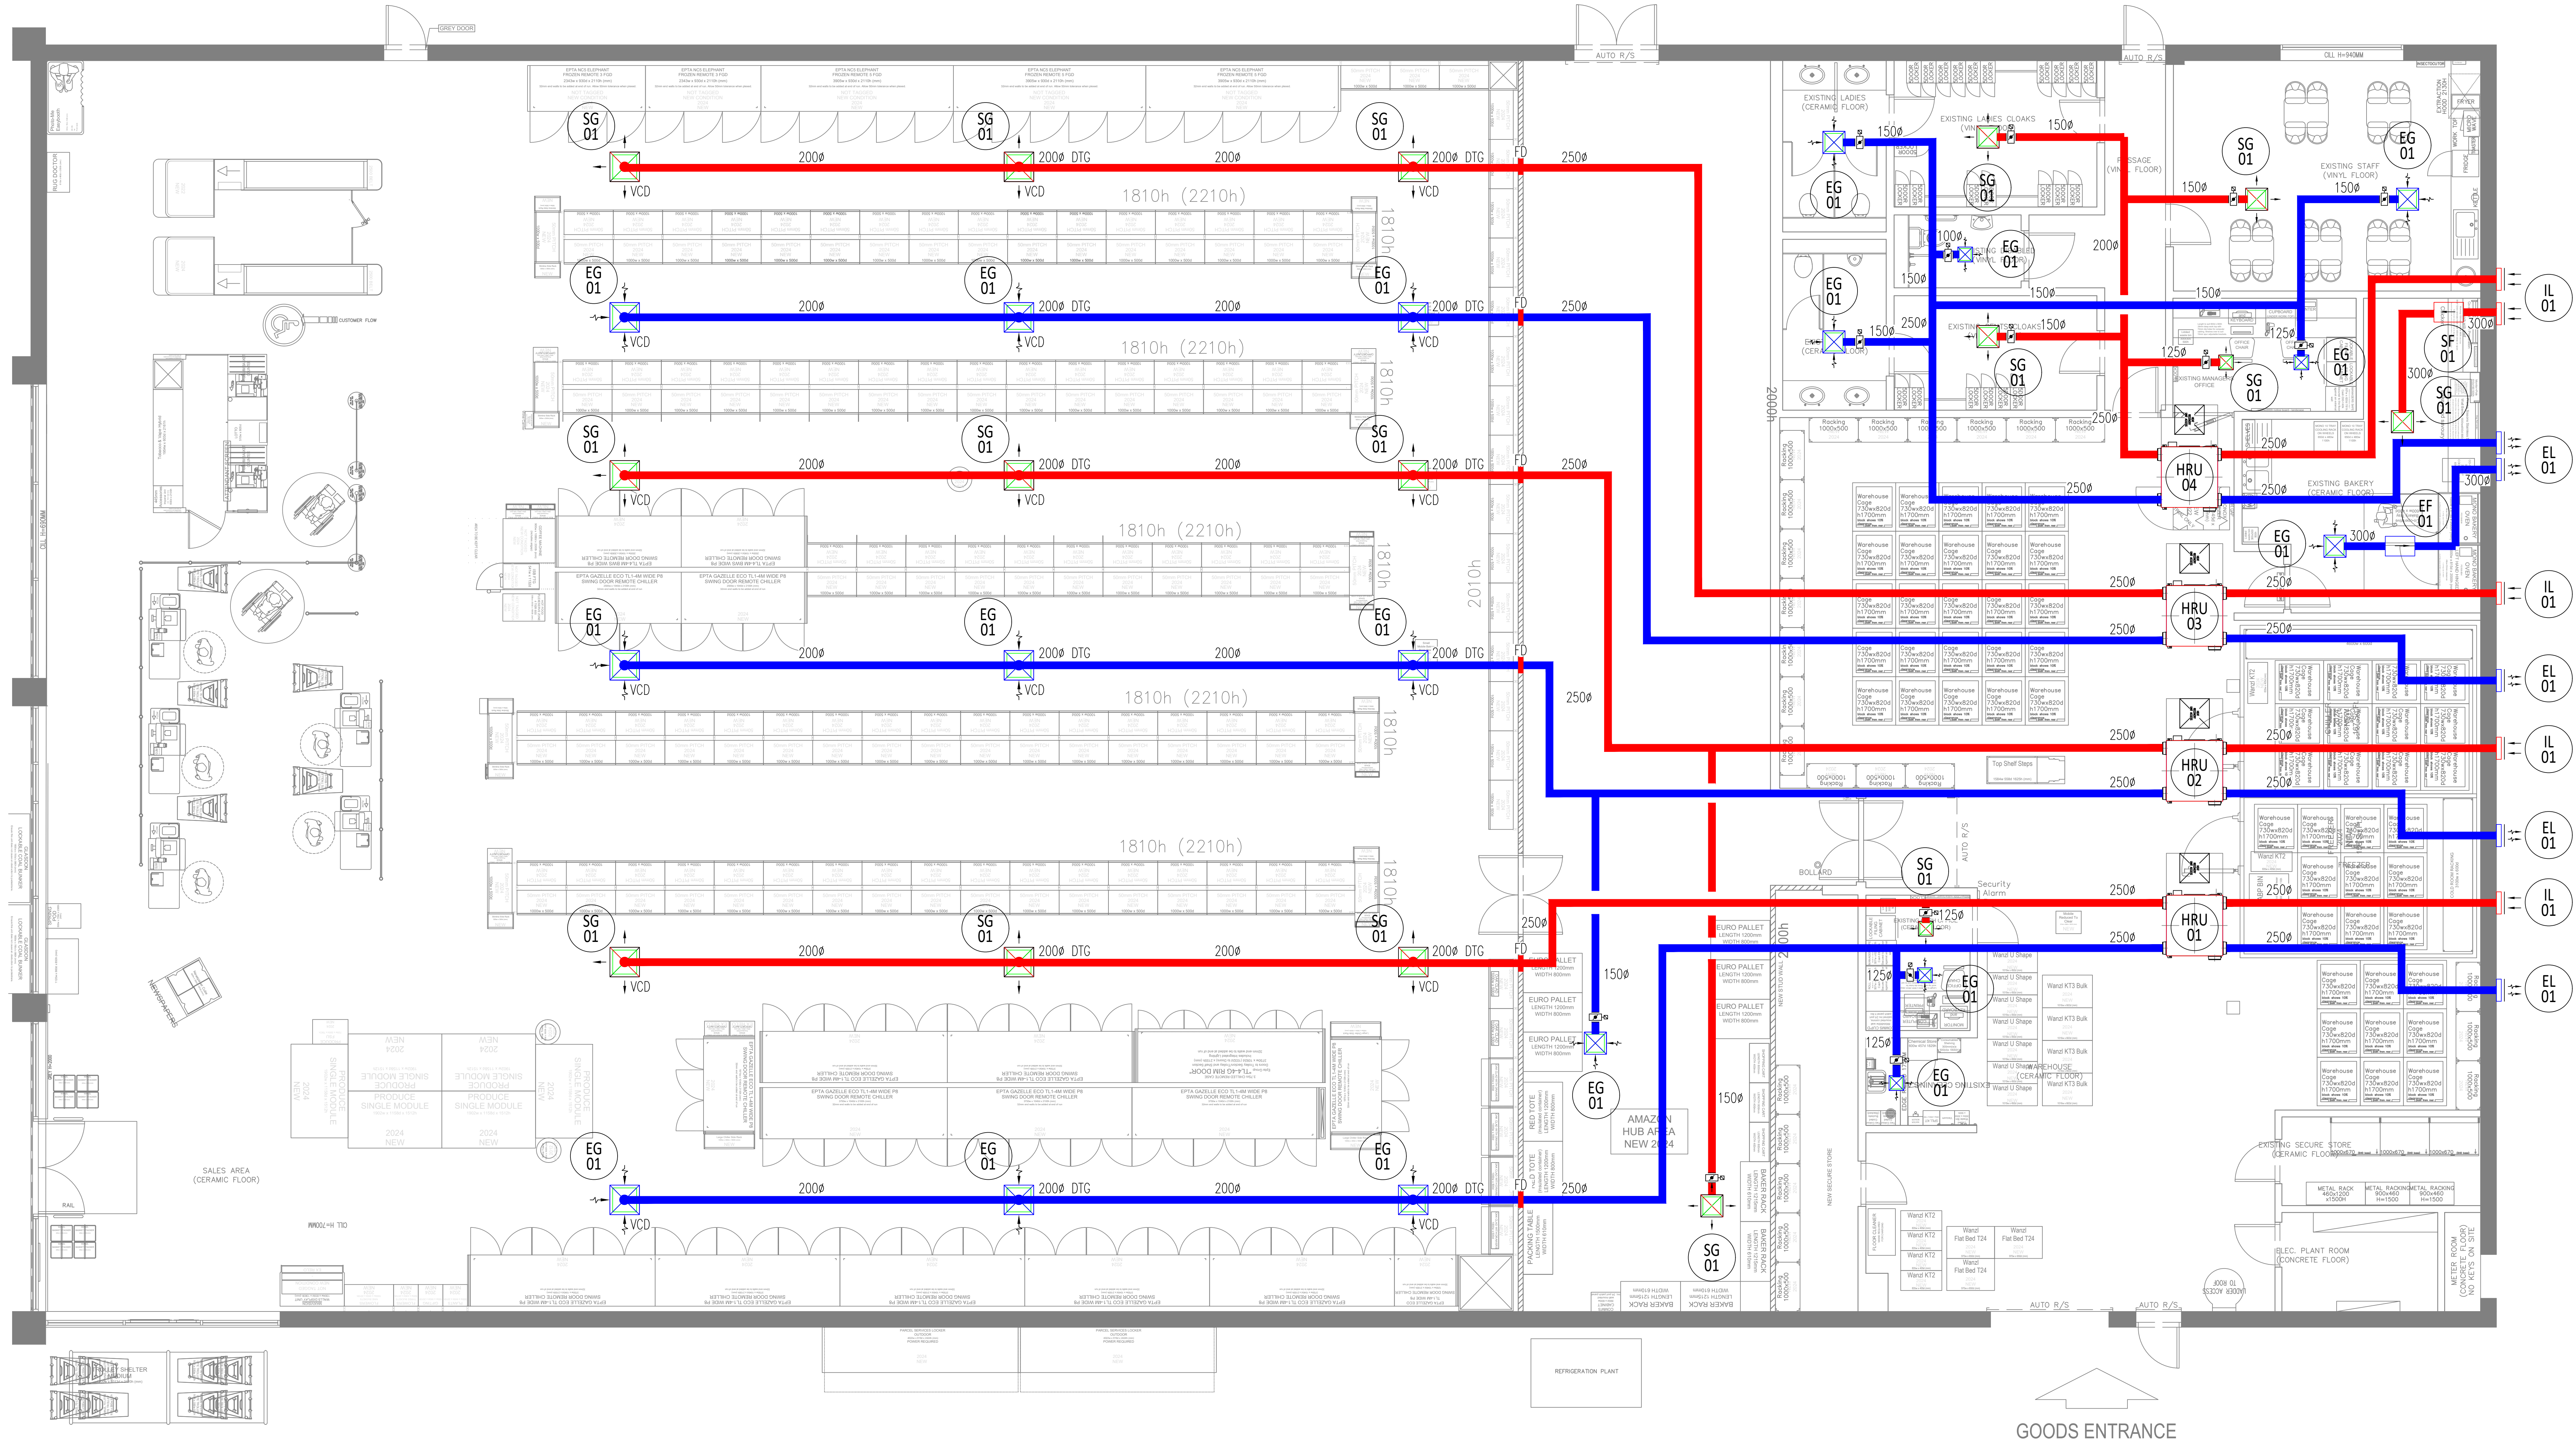

Rev	Summary of Alterations	By	Date
R10			
R9			
R8			
R7			
R6			
R5			
R4			
R3			
R2	VENTILATION SCHEDULE ADDED	NHH	15.04.24
R1	UPDATED TO STAGE 4	NHH	08.04.24

OHMEGA

Unit 7b Asquith Business Park,
Asquith Avenue,
Morley,
Leeds LS27 7RZ

Call: 0113 252 4973
Email: info@ohmega-group
Web: www.ohmega-group

Client

BRIDFORD INTERIORS

coop

Project Title
Coop - Earl Shilton
Wood St, Earl Shilton
Leicestershire, LE9 7ND
Drawing Title
Ground Floor
Ventilation Services Layout

FOR COMMENT APPROVED	☐	FOR APPROVAL REJECTED	☒
TENDER DRAWING AS FITTED	☐	CONSTRUCTION FINALISED	☐

Drawn: NHH	Date: 17.03.24
Approved: MA	Date: 20.03.24
Scale: 1:50	Paper Size A0
Department RETAIL	
Dwg No: 423191/M/1003	Rev: R2