



PLANNING ISSUE

REVISIONS:				
REV	DESCRIPTION	DATE	CHK	APP
A	PRE APP PLANNING ISSUE	24-10-22	MS	MS
B	PRE APP PLANNING ISSUE	11-04-23	MS	MS
C	PLANNING ISSUE	05-05-23	MS	MS
D	PLANNING ISSUE	11-05-23	MS	MS
E	PLANNING ISSUE	17-05-23	MS	MS
F	PLANNING ISSUE	19-05-23	MS	MS
G	PLANNING ISSUE	12-09-23	MS	MS
H	PLANNING ISSUE	23-02-23	MS	MS
I	PLANNING ISSUE	28-02-23	MS	MS
J	PLANNING ISSUE	24-04-24	MS	MS
K	PLANNING ISSUE	11-07-25	MS	MS
L	PLANNING ISSUE	20-01-26	MS	MS

KEY

- SECURITY PALISADE FENCE 2.4m HIGH
- SITE BOUNDARY FENCE V MESH IN BLACK 2.4m HIGH
- SITE BOUNDARY FENCE CLOSE BOARDED TIMBER 2.4m HIGH
- SURFACE CHANNEL FOR BELOW GROUND PIPE ROUTING.
- CRASH BARRIER
- NEW TREES
- PROPOSED GRASSED LANDSCAPED AREA
- PROPOSED HEDGEROW
- EXISTING LEYLANDII TREES
- EXISTING HEDGEROW
- EXISTING TREE / VEGETATION ROAD SCREENING

CLIENT:

PROJECT:
HINCKLEY CNG STATION
WATLING STREET

TITLE:
PROPOSED CNG STATION
SITE LIGHTING PLAN

SCALE: 1:500 @ A3 DRAWN: KJB
CHECKED: MS CAD: DATE: 11-10-2022
APPROVED: MS SHEET: 1 OF 1


PROJECT No: 042

DRAWING No: 042-01-CNG-106


REVISION: L



THOMAS HOUSE
84 ECCLESTON SQUARE
LONDON
SW1V 1PX
TEL: 0203 961 9925
WEB: www.cngfuels.com

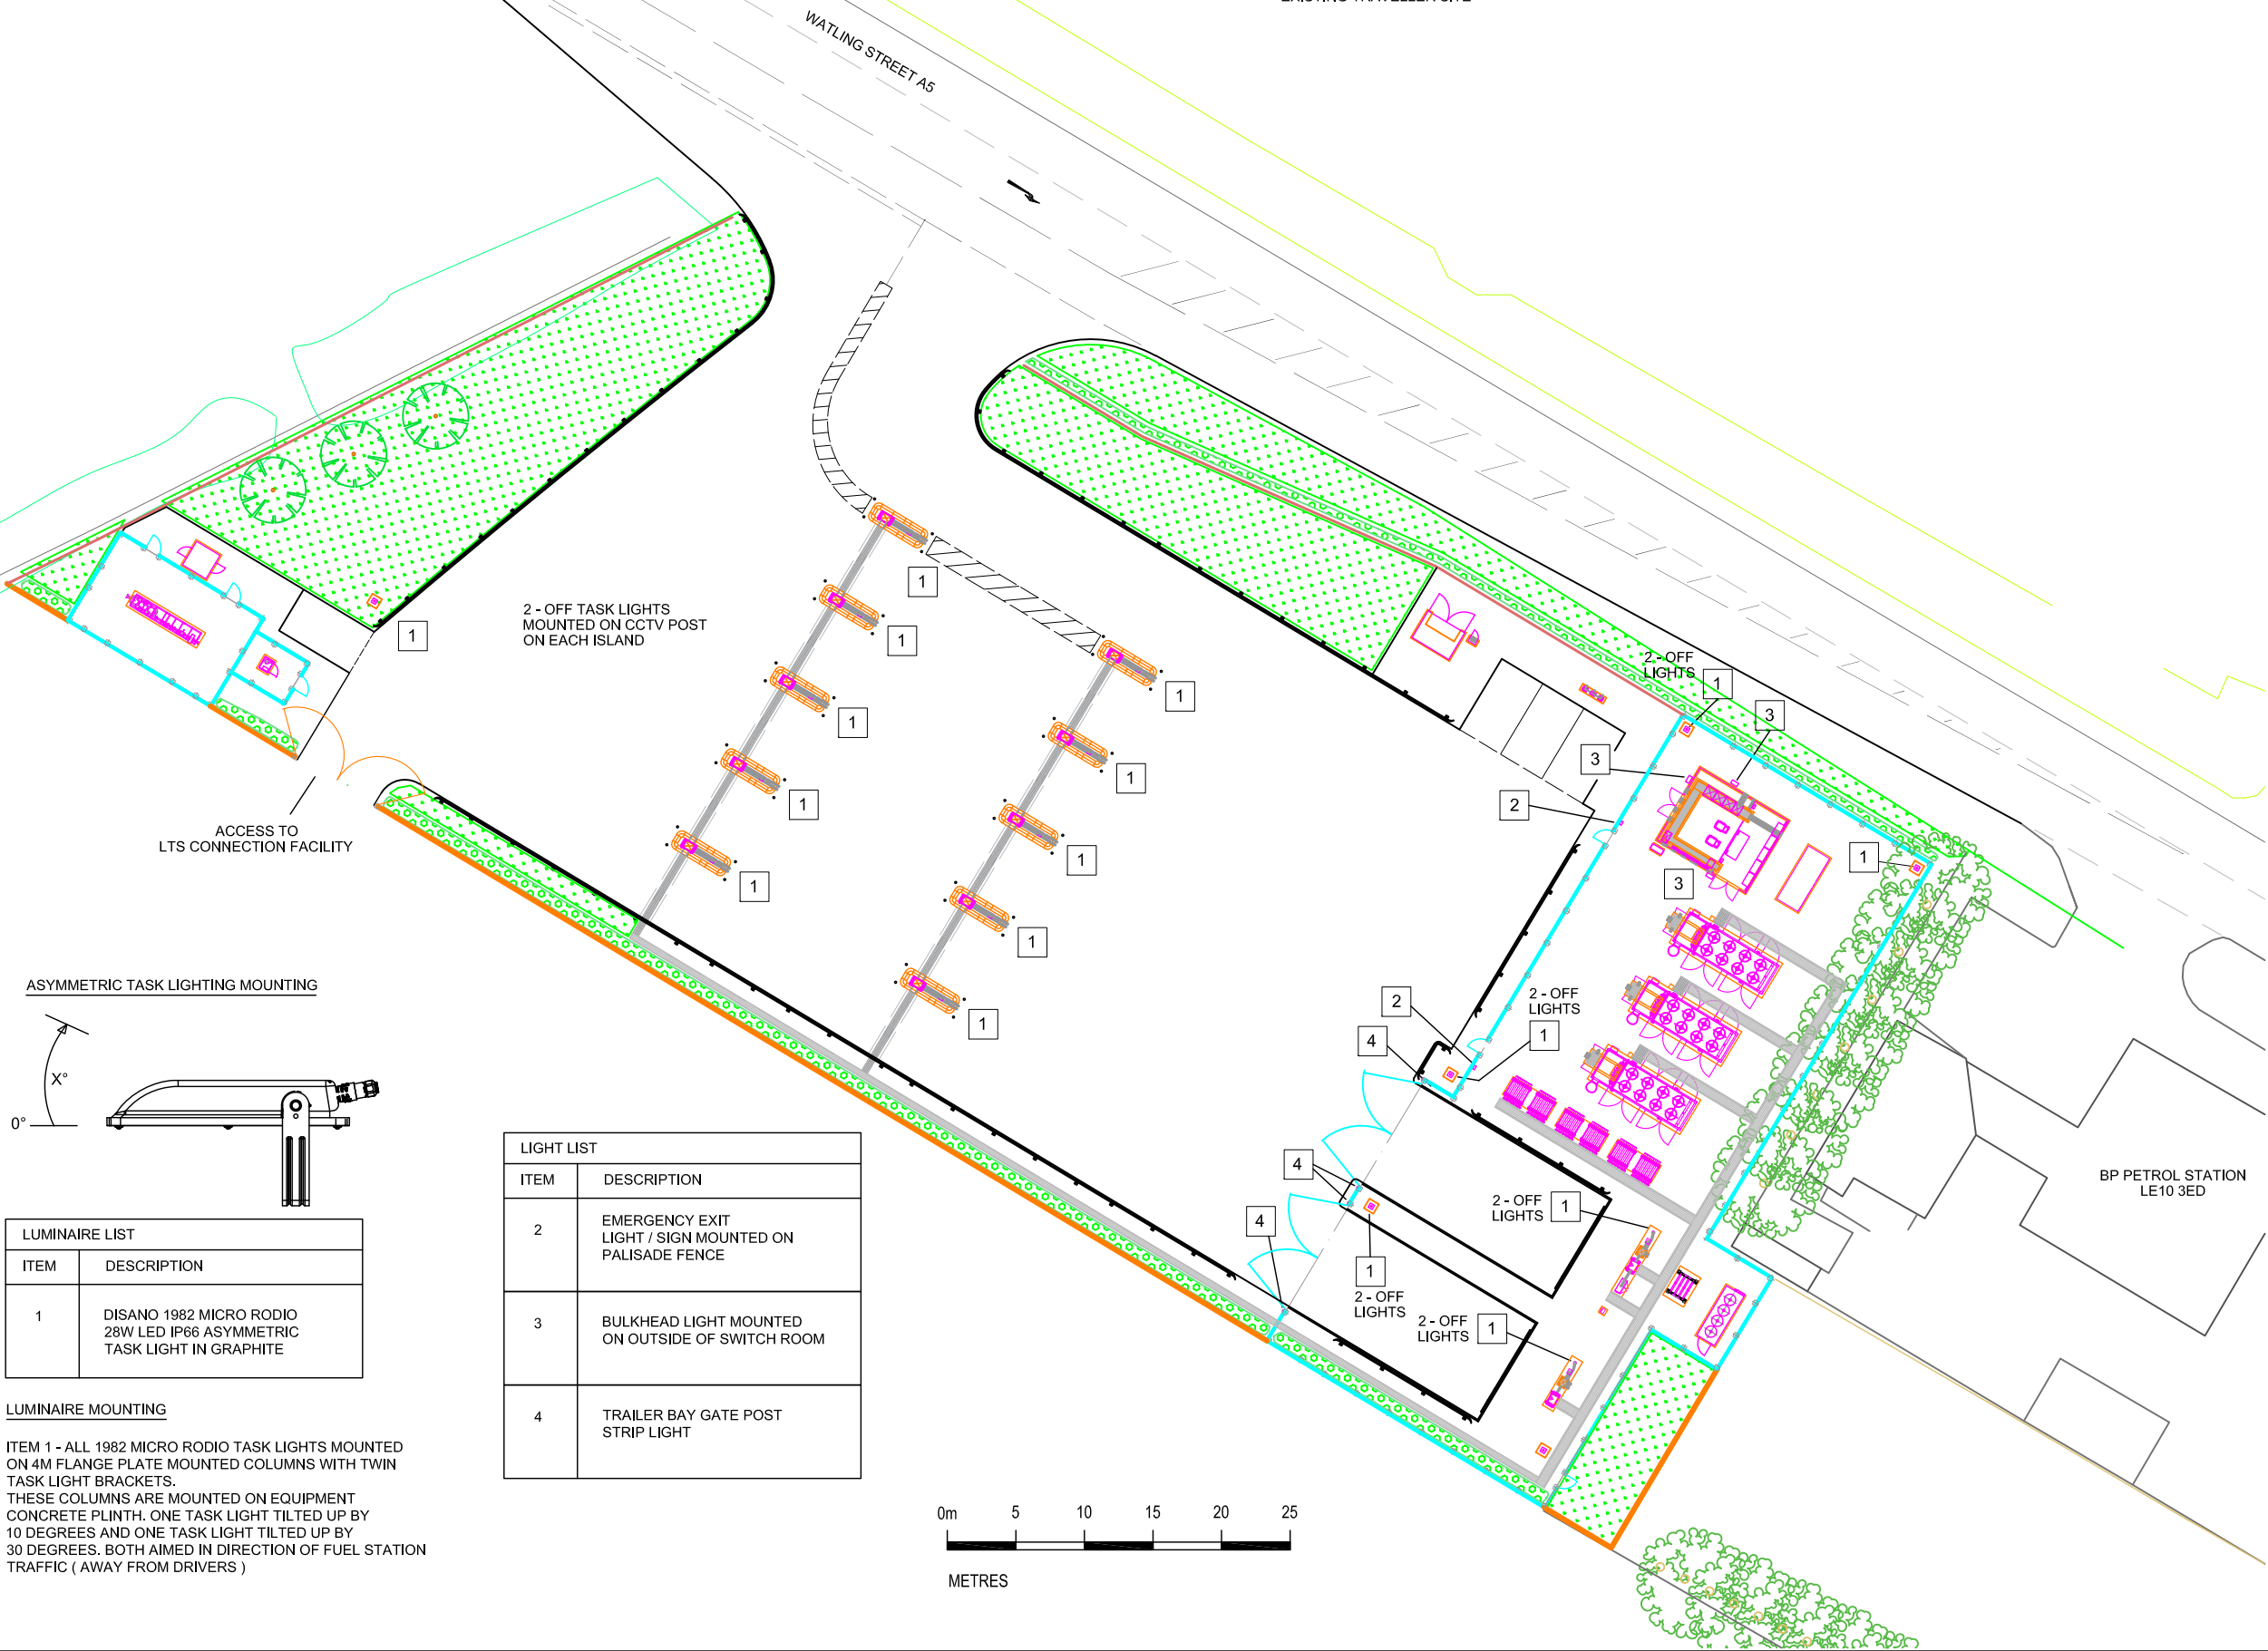

ASYMMETRIC TASK LIGHTING MOUNTING

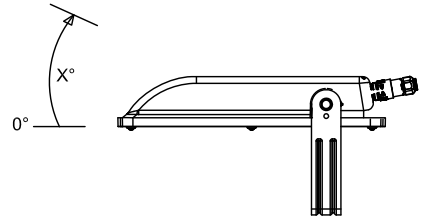

LUMINAIRE LIST	
ITEM	DESCRIPTION
1	DISANO 1982 MICRO RODIO 28W LED IP66 ASYMMETRIC TASK LIGHT IN GRAPHITE

LUMINAIRE MOUNTING

ITEM 1 - ALL 1982 MICRO RODIO TASK LIGHTS MOUNTED ON 4M FLANGE PLATE MOUNTED COLUMNS WITH TWIN TASK LIGHT BRACKETS. THESE COLUMNS ARE MOUNTED ON EQUIPMENT CONCRETE PLINTH. ONE TASK LIGHT TILTED UP BY 10 DEGREES AND ONE TASK LIGHT TILTED UP BY 30 DEGREES. BOTH AIMED IN DIRECTION OF FUEL STATION TRAFFIC (AWAY FROM DRIVERS)

LIGHT LIST	
ITEM	DESCRIPTION
2	EMERGENCY EXIT LIGHT / SIGN MOUNTED ON PALISADE FENCE
3	BULKHEAD LIGHT MOUNTED ON OUTSIDE OF SWITCH ROOM
4	TRAILER BAY GATE POST STRIP LIGHT

